



GRIFFITHS DUPLEX

980 HAND STREET, FERNIE BC



DRAWING INDEX

- A1.1 SITE PLAN
- A2.1 CRAWLSPACE PLAN
- A2.1 MAIN FLOOR PLAN
- A2.2 SECOND FLOOR PLAN
- A2.3 ROOF PLAN
- A3.1 FRONT ELEVATION
- A3.2 REAR ELEVATION
- A3.3 SIDE ELEVATIONS
- A3.4 BUILDING SECTION I
- PARTY WALL FLOOR DETAIL
- A3.5 BUILDING SECTION II
- A3.5 BUILDING SECTION III
- A3.6 BUILDING SECTION IV
- E1.1 CRAWLSPACE ELECTRICAL PLAN
- E1.2 MAIN FLOOR ELECTRICAL PLAN
- E1.3 SECOND FLOOR ELECTRICAL PLAN

ISSUE FOR REVIEW

GENERAL NOTES

- PLEASE READ CAREFULLY BEFORE BEGINNING PROJECT
1. WHILE EVERY ATTEMPT HAS BEEN MADE IN THE PREPARATION OF THIS PLAN TO AVOID MISTAKES, THE DESIGNER CANNOT GUARANTEE AGAINST HUMAN ERROR.
 2. THE DESIGNER IS UNABLE TO ACCEPT ANY LIABILITY FOR THE ACCURACY OR OVERALL INTEGRITY OF THESE DRAWINGS.
 3. DRAWINGS ARE NOT TO BE SCALED.
 4. ALL DRAWINGS, DIMENSIONS, DETAILS, AND NOTES TO BE REVIEWED AND CONFIRMED BY THE GENERAL CONTRACTOR BEFORE UNDERTAKING ANY WORK ON THE PROJECT. ANY DISCREPANCIES, ERRORS OR OMISSIONS TO BE REPORTED TO THE DESIGNER IMMEDIATELY, BEFORE ORDERING MATERIALS OR COMMENCING CONSTRUCTION.
 5. DESIGNER IS NOT RESPONSIBLE FOR ERRORS AND OMISSIONS IN STRUCTURAL DESIGN. ALL STRUCTURAL SYSTEMS TO BE ENGINEERED BY OTHERS. STRUCTURAL LOCATIONS AND SIZES OF SONOTUBES, COLUMNS, FOOTINGS, AND BEAMS ARE A GUIDE ONLY; THEY MUST BE VERIFIED BY TRUSS / FLOOR MANUFACTURER BEFORE CONSTRUCTION BEGINS.
 6. ALL SITE DIMENSIONS AND MEASUREMENTS ARE TO BE GOVERNED AND APPROVED BY MUNICIPAL AUTHORITIES BEFORE STARTING CONSTRUCTION.
 7. ALL CONSTRUCTION TO COMPLY WITH CURRENT BUILDING CODE, REGULATIONS, RULES AND BYLAWS SET BY THE AUTHORITY HAVING JURISDICTION.
 8. ALL CONSTRUCTION TO COMPLY WITH INDUSTRY TRADE STANDARDS AND MANUFACTURER'S RECOMMENDATIONS WHERE THESE INSTRUCTIONS AND RECOMMENDATIONS ARE MORE STRINGENT THAN THAT CONTAINED ON THE DRAWING. ALL MATERIALS AND ENGINEERED COMPONENTS TO BE INSTALLED TO MANUFACTURER'S SPECIFICATIONS AND AS PER ENGINEERED DRAWINGS.
 9. FOUNDATION AND FOOTING DESIGN ARE TYPICAL ONLY AND ASSUME STANDARD SOIL CONDITIONS AS OUTLINED IN THE BC BUILDING CODE, LATEST EDITION. IT IS THE RESPONSIBILITY OF THE OWNER / GENERAL CONTRACTOR TO CONFIRM SITE CONDITIONS AND PROVIDE ENGINEERING IF REQUIRED.
 10. GENERAL CONTRACTOR TO CONFIRM FOUNDATION WALLS MEET THE REQUIRED BACKFILL HEIGHTS, SPECIFIED WALLS AND GRADES TO BE ADJUSTED TO SUIT SITE CONDITIONS. EXTERIOR GRADES & RAIL ELEMENTS AFFECTED BY FINAL GRADE ARE TO BE CONFIRMED PRIOR TO CONSTRUCTION (BY OTHER).
 11. ALL WOOD FRAMING TO BE SPF #2 OR BETTER. ANY LUMBER IN CONTACT WITH CONCRETE MUST BE "PRESERVED WOOD FOUNDATION" (PW) MATERIAL.
 12. ALL LOADING & DRIFTING ARE TO BE DESIGNED BY OTHERS.
 13. PLUMBING, ELECTRICAL & HEATING BY CONTRACTOR TO CODE, LATEST EDITION.
 14. ROOF VENTS INSTALLED IN ACCORDANCE WITH THE BC BUILDING CODE 9.19.1.
 15. IN-FLOOR HEATED CONCRETE SYSTEM BY OTHERS. PROVISIONS TO BE MADE FOR SOIL GAS CONTROL AS PER BC BUILDING CODE 9.13.4.
 17. STAIRS AND HANDRAILS INSTALLED IN ACCORDANCE WITH THE BC BUILDING CODE 9.8.
 18. DOOR AND WINDOW SIZES ARE APPROXIMATE AND MAY VARY BETWEEN MANUFACTURERS. ACTUAL SIZES AND ROUGH OPENINGS TO BE OBTAINED FROM SUPPLIER. ALL DOORS & WINDOWS MUST BE MARK COMPLIANT WHERE APPLICABLE AND IN ACCORDANCE WITH BC BUILDING CODE. DOORS BETWEEN HOUSE AND GARAGE TO HAVE SELF-CLOSING MECHANISM AND WEATHER STRIPPING. FIRE RATED DOORS / w SELF CLOSURES TO BE INSTALLED IN ALL FIRE RATED WALLS.
 19. INFORMATION ON THESE DRAWINGS ASSUME THE AREA OF DOORS AND WINDOWS DO NOT EXCEED THE MAXIMUM RATIO TO WALL AREA OF 25% UNLESS NOTED OTHERWISE.
 20. WALLS GREATER THAN 12'-0" IN HEIGHT TO COMPLY WITH THE LOCAL JURISDICTION'S GLUE FOR TALL WALLS (WHERE APPLICABLE) OR BE ENGINEERED.
 21. WORKING DRAWINGS ARE A GRAPHIC REPRESENTATION ONLY - ACTUAL PRODUCTS AND MATERIALS USED MAY VARY FROM THE DEPICTION ON DRAWING.
 22. ENGINEERS DRAWINGS AND/OR STAMP AS REQUIRED SHALL BE THE RESPONSIBILITY OF THE GENERAL CONTRACTOR AND/OR THE OWNER.
 23. ANYTHING NOT COVERED IN THE PLANS WILL BE OPEN FOR NEGOTIATION BETWEEN THE OWNER AND THE GENERAL CONTRACTOR.

THE INFORMATION CONTAINED ON THIS DRAWING HAS BEEN PREPARED FOR THE SOLE PURPOSE OF THE PROJECT DESCRIBED HEREIN AND FOR THE SOLE BENEFIT OF THE OWNER. USE OF THIS INFORMATION FOR ANY PURPOSE OTHER THAN THE PROJECT DESCRIBED HEREIN IS AT THE SOLE RISK OF THE USER. ANY UNAUTHORIZED USE OF THIS INFORMATION WILL BE CONSIDERED A BREACH OF COPYRIGHT AND MAY BE PURSUED AS SUCH.



TIMBERS
home + building design

T 250 489 9022 | E kim@timbershbd.com

CLIENT

**GRIFFITHS
DUPLEX**

PROJECT ADDRESS
980 HAND STREET
FERNIE, BC

LEGAL ADDRESS
LOT 1/A, PLAN NEP15240,
DL 5455, KOOTENAY DISTRICT
PID: 009-503-340

DRAWING

TITLE PAGE


7			
6			
5			
4			
3			
2			
1			

No	REVISION	DATE	BY
1	ISSUE FOR REVIEW	11 MAR	KD

DATE	PAGE No.
11-MAR-24	

SCALE
NOT TO SCALE

S T R E E T

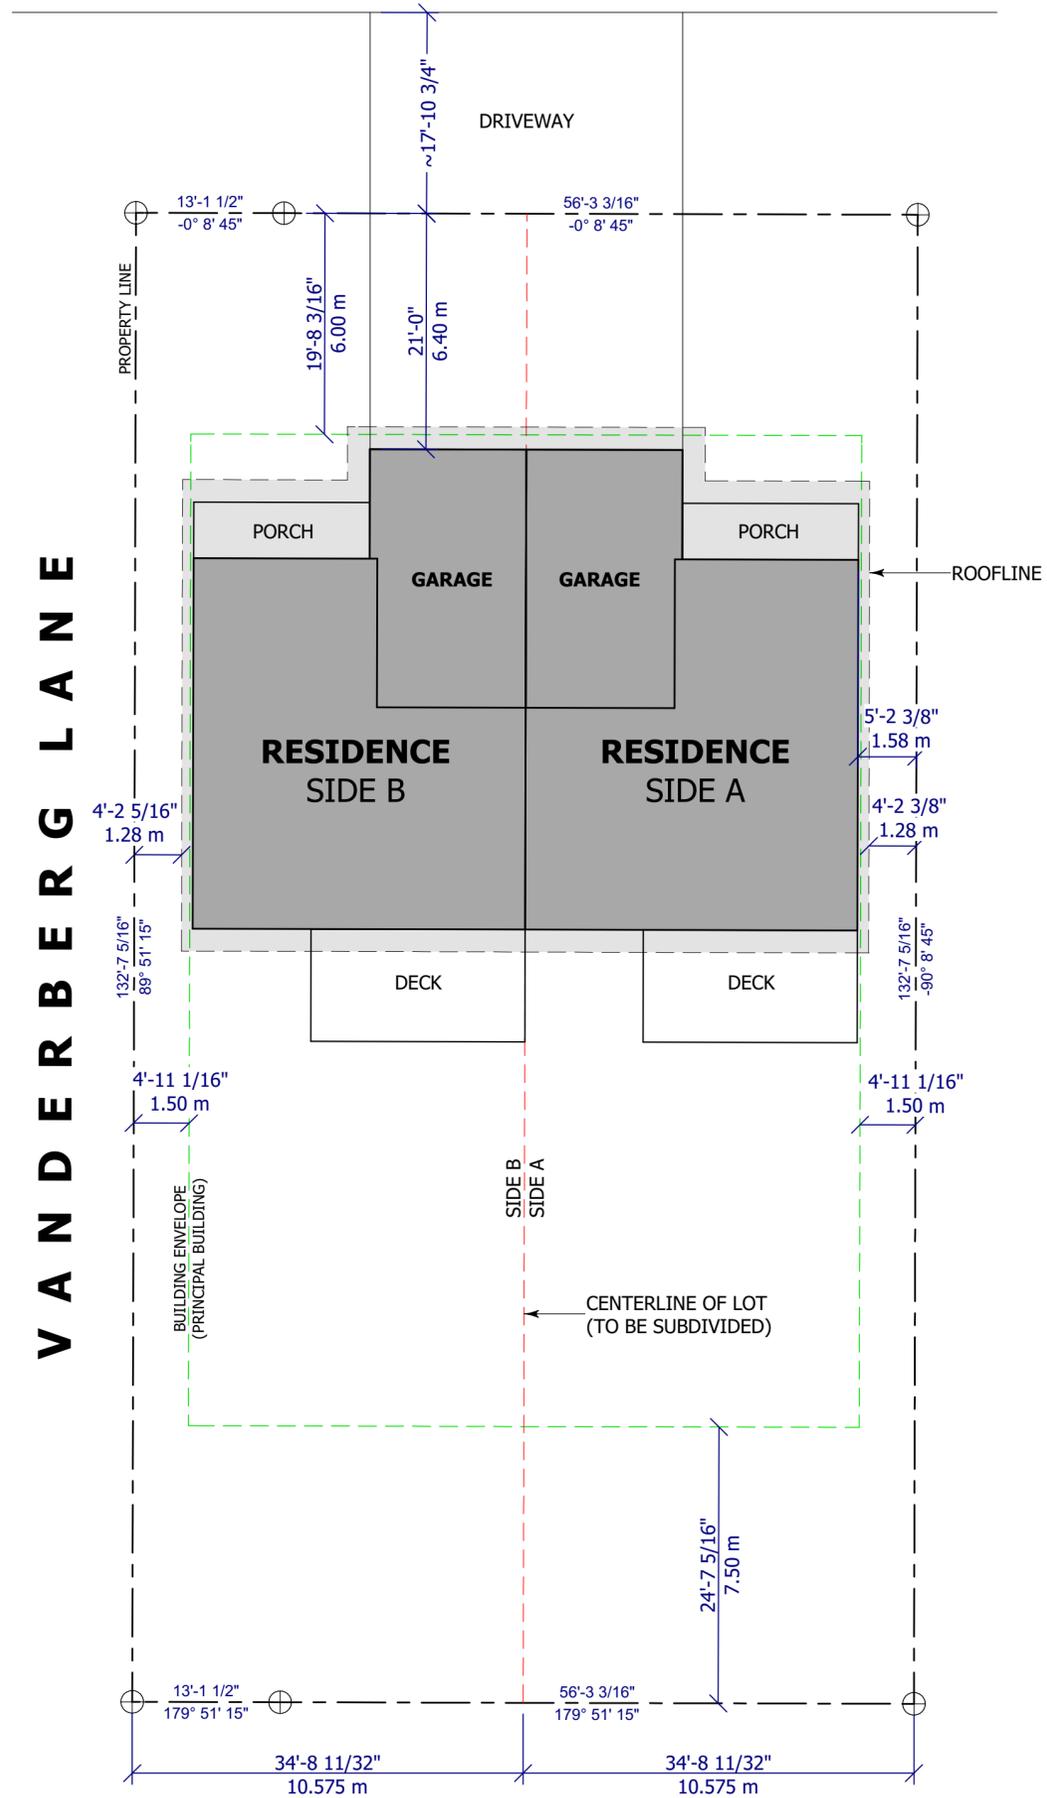

LOT 1	
ZONING BYLAW	R-WF
LOT SIZE	854.9 sq m 9,201.9 sq ft
PERMITTED LOT COVERAGE	
ALL STRUCTURES	30 % 2,760.6 sq ft
INCLUDING DECKS	35 % 3,220.7 sq ft
PROPOSED LOT COVERAGE	
ALL STRUCTURES	24.1 % 2,217.6 sq ft
INCLUDING DECKS	29.9 % 2,754 sq ft
1,108.8 sq ft	HOUSE & GARAGE A
1,108.8 sq ft	HOUSE & GARAGE B
2,217.6 sq ft	SUB TOTAL
268.2 sq ft	DECK & PORCH A
268.2 sq ft	DECK & PORCH B
2,754.0 sq ft	TOTAL
FLOOD CONSTRUCTION LEVEL	996.8 m
MAX. PRINCIPAL BUILDING HEIGHT	9.0 m 29'-6"
MAX. ACCESSORY BUILDING HEIGHT	5.0 m 16'-4 7/8"
MAX. ACCESSORY BUILDING HEIGHT WITH SECONDARY DWELLING UNIT	7.5 m 24'-7 1/4"



GENERAL NOTES

- PLEASE READ CAREFULLY BEFORE BEGINNING PROJECT
1. WHILE EVERY ATTEMPT HAS BEEN MADE IN THE PREPARATION OF THIS PLAN TO AVOID MISTAKES, THE DESIGNER CANNOT GUARANTEE AGAINST HUMAN ERROR.
 2. THE DESIGNER IS UNABLE TO ACCEPT ANY LIABILITY FOR THE ACCURACY OR OVERALL INTEGRITY OF THESE DRAWINGS.
 3. DRAWINGS ARE NOT TO BE SCALED.
 4. ALL DRAWINGS, DIMENSIONS, DETAILS, AND NOTES TO BE REVIEWED AND CONFIRMED BY THE GENERAL CONTRACTOR BEFORE UNDERTAKING ANY WORK ON THE PROJECT. ANY DISCREPANCIES, ERRORS OR OMISSIONS TO BE REPORTED TO THE DESIGNER IMMEDIATELY BEFORE ORDERING MATERIALS OR COMMENCING CONSTRUCTION.
 5. DESIGNER IS NOT RESPONSIBLE FOR ERRORS AND OMISSIONS IN STRUCTURAL DESIGN. ALL STRUCTURAL SYSTEMS TO BE ENGINEERED BY OTHERS. STRUCTURAL LOCATIONS AND SIZES OF SONOTUBES, COLUMNS, FOOTINGS, AND BEAMS ARE A GUIDE ONLY; THEY MUST BE VERIFIED BY TRUSS / FLOOR MANUFACTURER BEFORE CONSTRUCTION BEGINS.
 6. ALL SITE DIMENSIONS AND MEASUREMENTS ARE TO BE GOVERNED AND APPROVED BY MUNICIPAL AUTHORITIES BEFORE STARTING CONSTRUCTION.
 7. ALL CONSTRUCTION TO COMPLY WITH CURRENT BUILDING CODE, REGULATIONS, RULES AND BYLAWS SET BY THE AUTHORITY HAVING JURISDICTION.
 8. ALL CONSTRUCTION TO COMPLY WITH INDUSTRY TRADE STANDARDS AND MANUFACTURER'S RECOMMENDATIONS WHERE THESE INSTRUCTIONS AND RECOMMENDATIONS ARE MORE STRINGENT THAN THAT CONTAINED ON THE DRAWING. ALL MATERIALS AND ENGINEERED COMPONENTS TO BE INSTALLED TO MANUFACTURER'S SPECIFICATIONS AND AS PER ENGINEERED DRAWINGS.
 9. FOUNDATION AND FOOTING DESIGN ARE TYPICAL ONLY AND ASSUME STANDARD SOIL CONDITIONS AS OUTLINED IN THE BC BUILDING CODE, LATEST EDITION. IT IS THE RESPONSIBILITY OF THE OWNER / GENERAL CONTRACTOR TO CONFIRM SITE CONDITIONS AND PROVIDE ENGINEERING IF REQUIRED.
 10. GENERAL CONTRACTOR TO CONFIRM FOUNDATION WALLS MEET THE REQUIRED BACKFILL HEIGHTS, SPECIFIED WALLS AND GRADES TO BE ADJUSTED TO SUIT SITE CONDITIONS. EXTERIOR GRADES & ALL ELEMENTS AFFECTED BY FINAL GRADE ARE TO BE CONFIRMED PRIOR TO CONSTRUCTION (BY OTHER).
 11. ALL WOOD FRAMING TO BE SFF #2 OR BETTER. ANY LUMBER IN CONTACT WITH CONCRETE MUST BE "PRESERVED WOOD FOUNDATION" (PW) MATERIAL.
 12. ALL LOADING & DRIFTING ARE TO BE DESIGNED BY OTHERS.
 13. PLUMBING, ELECTRICAL & HEATING BY CONTRACTOR TO CODE, LATEST EDITION.
 14. ROOF VENTS INSTALLED IN ACCORDANCE WITH THE BC BUILDING CODE 9.13.1.
 15. IN-FLOOR HEATED CONCRETE SYSTEM BY OTHERS. PROVISIONS TO BE MADE FOR SOIL GAS CONTROL AS PER BC BUILDING CODE 9.13.4.
 17. STAIRS AND HANDRAILS INSTALLED IN ACCORDANCE WITH THE BC BUILDING CODE 9.8.
 18. DOOR AND WINDOW SIZES ARE APPROXIMATE AND MAY VARY BETWEEN MANUFACTURERS. ACTUAL SIZES AND ROUGH OPENINGS TO BE OBTAINED FROM SUPPLIER. ALL DOORS & WINDOWS MUST BE MARK COMPLIANT WHERE APPLICABLE AND IN ACCORDANCE WITH BC BUILDING CODE. DOORS BETWEEN HOUSE AND GARAGE TO HAVE SELF-CLOSING MECHANISM AND WEATHER STRIPPING. FIRE RATED DOORS / W SELF CLOSURES TO BE INSTALLED IN ALL FIRE RATED WALLS.
 19. INFORMATION ON THESE DRAWINGS ASSUME THE AREA OF DOORS AND WINDOWS DO NOT EXCEED THE MAXIMUM RATIO TO WALL AREA OF 25% UNLESS NOTED OTHERWISE.
 20. WALLS GREATER THAN 12'-0" IN HEIGHT TO COMPLY WITH THE LOCAL JURISDICTION'S GUIDE FOR TALL WALLS (WHERE APPLICABLE) OR BE ENGINEERED.
 21. WORKING DRAWINGS ARE A GRAPHIC REPRESENTATION ONLY - ACTUAL PRODUCTS AND MATERIALS USED MAY VARY FROM THE INDICATION ON DRAWING.
 22. ENGINEERS DRAWINGS AND/OR STAMP AS REQUIRED SHALL BE THE RESPONSIBILITY OF THE GENERAL CONTRACTOR AND/OR THE OWNER.
 23. ANYTHING NOT COVERED IN THE PLANS WILL BE OPEN FOR NEGOTIATION BETWEEN THE OWNER AND THE GENERAL CONTRACTOR.

THE INFORMATION CONTAINED ON THIS DRAWING HAS BEEN PREPARED FOR THE SOLE PURPOSE OF THE PROJECT DESCRIBED HEREIN AND FOR THE SOLE BENEFIT OF THE OWNER. USE OF THIS INFORMATION FOR ANY PURPOSE OTHER THAN THE PROJECT DESCRIBED HEREIN IS AT THE SOLE RISK OF THE USER. ANY UNAUTHORIZED USE OF THIS INFORMATION WILL BE CONSIDERED A BREACH OF COPYRIGHT AND MAY BE PURSUED AS SUCH.

TIMBERS
home + building design
T 250 489 9022 | E kim@timbershbd.com

GRIFFITHS DUPLEX

PROJECT ADDRESS
980 HAND STREET
FERNIE, BC

LEGAL ADDRESS
LOT 1/A, PLAN NEP15240,
DL 5455, KOOTENAY DISTRICT
PID: 009-503-340

SITE PLAN

7					
6					
5					
4					
3					
2					
1	ISSUE FOR REVIEW	11 MAR	KD		
No	REVISION	DATE	BY		

DATE: 11-MAR-24
SCALE: 3/32" = 1'-0"
A1.1

ISSUE FOR REVIEW

FLOODPLAIN
CONSTRUCTION
LEVEL: 996.8 m

GENERAL NOTES

- PLEASE READ CAREFULLY BEFORE BEGINNING PROJECT
1. WHILE EVERY ATTEMPT HAS BEEN MADE IN THE PREPARATION OF THIS PLAN TO AVOID MISTAKES, THE DESIGNER CANNOT GUARANTEE AGAINST HUMAN ERROR.
 2. THE DESIGNER IS UNABLE TO ACCEPT ANY LIABILITY FOR THE ACCURACY OR OVERALL INTEGRITY OF THESE DRAWINGS.
 3. DRAWINGS ARE NOT TO BE SCALED.
 4. ALL DIMENSIONS, DETAILS, AND NOTES TO BE REVIEWED AND CONFIRMED BY THE GENERAL CONTRACTOR BEFORE UNDERTAKING ANY WORK ON THE PROJECT. ANY DISCREPANCIES, ERRORS OR OMISSIONS TO BE REPORTED TO THE DESIGNER IMMEDIATELY BEFORE ORDERING MATERIALS OR COMMENCING CONSTRUCTION.
 5. DESIGNER IS NOT RESPONSIBLE FOR ERRORS AND OMISSIONS IN STRUCTURAL DESIGN. ALL STRUCTURAL SYSTEMS TO BE ENGINEERED BY OTHERS. STRUCTURAL LOCATIONS AND SIZES OF SONOTUBES, COLUMNS, FOOTINGS, AND BEAMS ARE A GUIDE ONLY; THEY MUST BE VERIFIED BY TRUSS / FLOOR MANUFACTURER BEFORE CONSTRUCTION BEGINS.
 6. ALL SITE DIMENSIONS AND MEASUREMENTS ARE TO BE GOVERNED AND APPROVED BY MUNICIPAL AUTHORITIES BEFORE STARTING CONSTRUCTION.
 7. ALL CONSTRUCTION TO COMPLY WITH CURRENT BUILDING CODE, REGULATIONS, RULES AND BYLAWS SET BY THE AUTHORITY HAVING JURISDICTION.
 8. ALL CONSTRUCTION TO COMPLY WITH INDUSTRY TRADE STANDARDS AND MANUFACTURER'S RECOMMENDATIONS WHERE THESE INSTRUCTIONS AND RECOMMENDATIONS ARE MORE STRINGENT THAN THAT CONTAINED ON THE DRAWING. ALL MATERIALS AND ENGINEERED COMPONENTS TO BE INSTALLED TO MANUFACTURER'S SPECIFICATIONS AND AS PER ENGINEERED DRAWINGS.
 9. FOUNDATION AND FOOTING DESIGN ARE TYPICAL ONLY AND ASSUME STANDARD SOIL CONDITIONS AS OUTLINED IN THE BC BUILDING CODE, LATEST EDITION. IT IS THE RESPONSIBILITY OF THE OWNER / GENERAL CONTRACTOR TO CONFIRM SITE CONDITIONS AND PROVIDE ENGINEERING IF REQUIRED.
 10. GENERAL CONTRACTOR TO CONFIRM FOUNDATION WALLS MEET THE REQUIRED BACKFILL HEIGHTS, SPECIFIED WALLS AND GRADES TO BE ADJUSTED TO SUIT SITE CONDITIONS. EXTERIOR GRADE & ALL ELEMENTS AFFECTED BY FINAL GRADE ARE TO BE CONFIRMED PRIOR TO CONSTRUCTION (BY OTHER).
 11. ALL WOOD FRAMING TO BE SFF #2 OR BETTER. ANY LUMBER IN CONTACT WITH CONCRETE MUST BE "PRESERVED WOOD FOUNDATION" (PW) MATERIAL.
 12. ALL LOADING & DRIFTING ARE TO BE DESIGNED BY OTHERS.
 13. PLUMBING, ELECTRICAL & HEATING BY CONTRACTOR TO CODE, LATEST EDITION.
 14. ROOF VENTS INSTALLED IN ACCORDANCE WITH THE BC BUILDING CODE 9.13.1.
 15. IN-FLOOR HEATED CONCRETE SYSTEM BY OTHERS. PROVISIONS TO BE MADE FOR SOIL GAS CONTROL AS PER BC BUILDING CODE 9.13.4.
 17. STAIRS AND HANDRAILS INSTALLED IN ACCORDANCE WITH THE BC BUILDING CODE 9.8.
 18. DOOR AND WINDOW SIZES ARE APPROXIMATE AND MAY VARY BETWEEN MANUFACTURERS. ACTUAL SIZES AND ROUGH OPENINGS TO BE OBTAINED FROM SUPPLIER. ALL DOORS & WINDOWS MUST BE MARK COMPLIANT WHERE APPLICABLE AND IN ACCORDANCE WITH BC BUILDING CODE. DOORS BETWEEN HOUSE AND GARAGE TO HAVE SELF-CLOSING MECHANISM AND WEATHER STRIPPING. FIRE RATED DOORS / W SELF CLOSURES TO BE INSTALLED IN ALL FIRE RATED WALLS.
 19. INFORMATION ON THESE DRAWINGS ASSUME THE AREA OF DOORS AND WINDOWS DO NOT EXCEED THE MAXIMUM RATIO TO WALL AREA OF 25% UNLESS NOTED OTHERWISE.
 20. WALLS GREATER THAN 12'-0" IN HEIGHT TO COMPLY WITH THE LOCAL JURISDICTION'S GLUE FOR TALL WALLS (WHERE APPLICABLE) OR BE ENGINEERED.
 21. WORKING DRAWINGS ARE A GRAPHIC REPRESENTATION ONLY - ACTUAL PRODUCTS AND MATERIALS USED MAY VARY FROM THE DIRECTION ON DRAWING.
 22. ENGINEERS DRAWINGS AND/OR STAMP AS REQUIRED SHALL BE THE RESPONSIBILITY OF THE GENERAL CONTRACTOR AND/OR THE OWNER.
 23. ANYTHING NOT COVERED IN THE PLANS WILL BE OPEN FOR NEGOTIATION BETWEEN THE OWNER AND THE GENERAL CONTRACTOR.

THE INFORMATION CONTAINED ON THIS DRAWING HAS BEEN PREPARED FOR THE SOLE PURPOSE OF THE PROJECT DESCRIBED HEREIN AND FOR THE SOLE BENEFIT OF THE OWNER. USE OF THIS INFORMATION FOR ANY PURPOSE OTHER THAN THE PROJECT DESCRIBED HEREIN IS AT THE SOLE RISK OF THE USER. ANY UNAUTHORIZED USE OF THIS INFORMATION WILL BE CONSIDERED A BREACH OF COPYRIGHT AND MAY BE PUNISHED AS SUCH.



TIMBERS
home + building design

T 250 489 9022 | E kin@timbershb.com

CLIENT
**GRIFFITHS
DUPLEX**

PROJECT ADDRESS
980 HAND STREET
FERNIE, BC

LEGAL ADDRESS
LOT 1/A, PLAN NEP15240,
DL 5455, KOOTENAY DISTRICT
PID: 009-503-340


CRAWLSPACE PLAN

No	REVISION	DATE	BY
1	ISSUE FOR REVIEW	11 MAR	KD

DATE
11-MAR-24

SCALE
1/4" = 1'-0"

A2.1

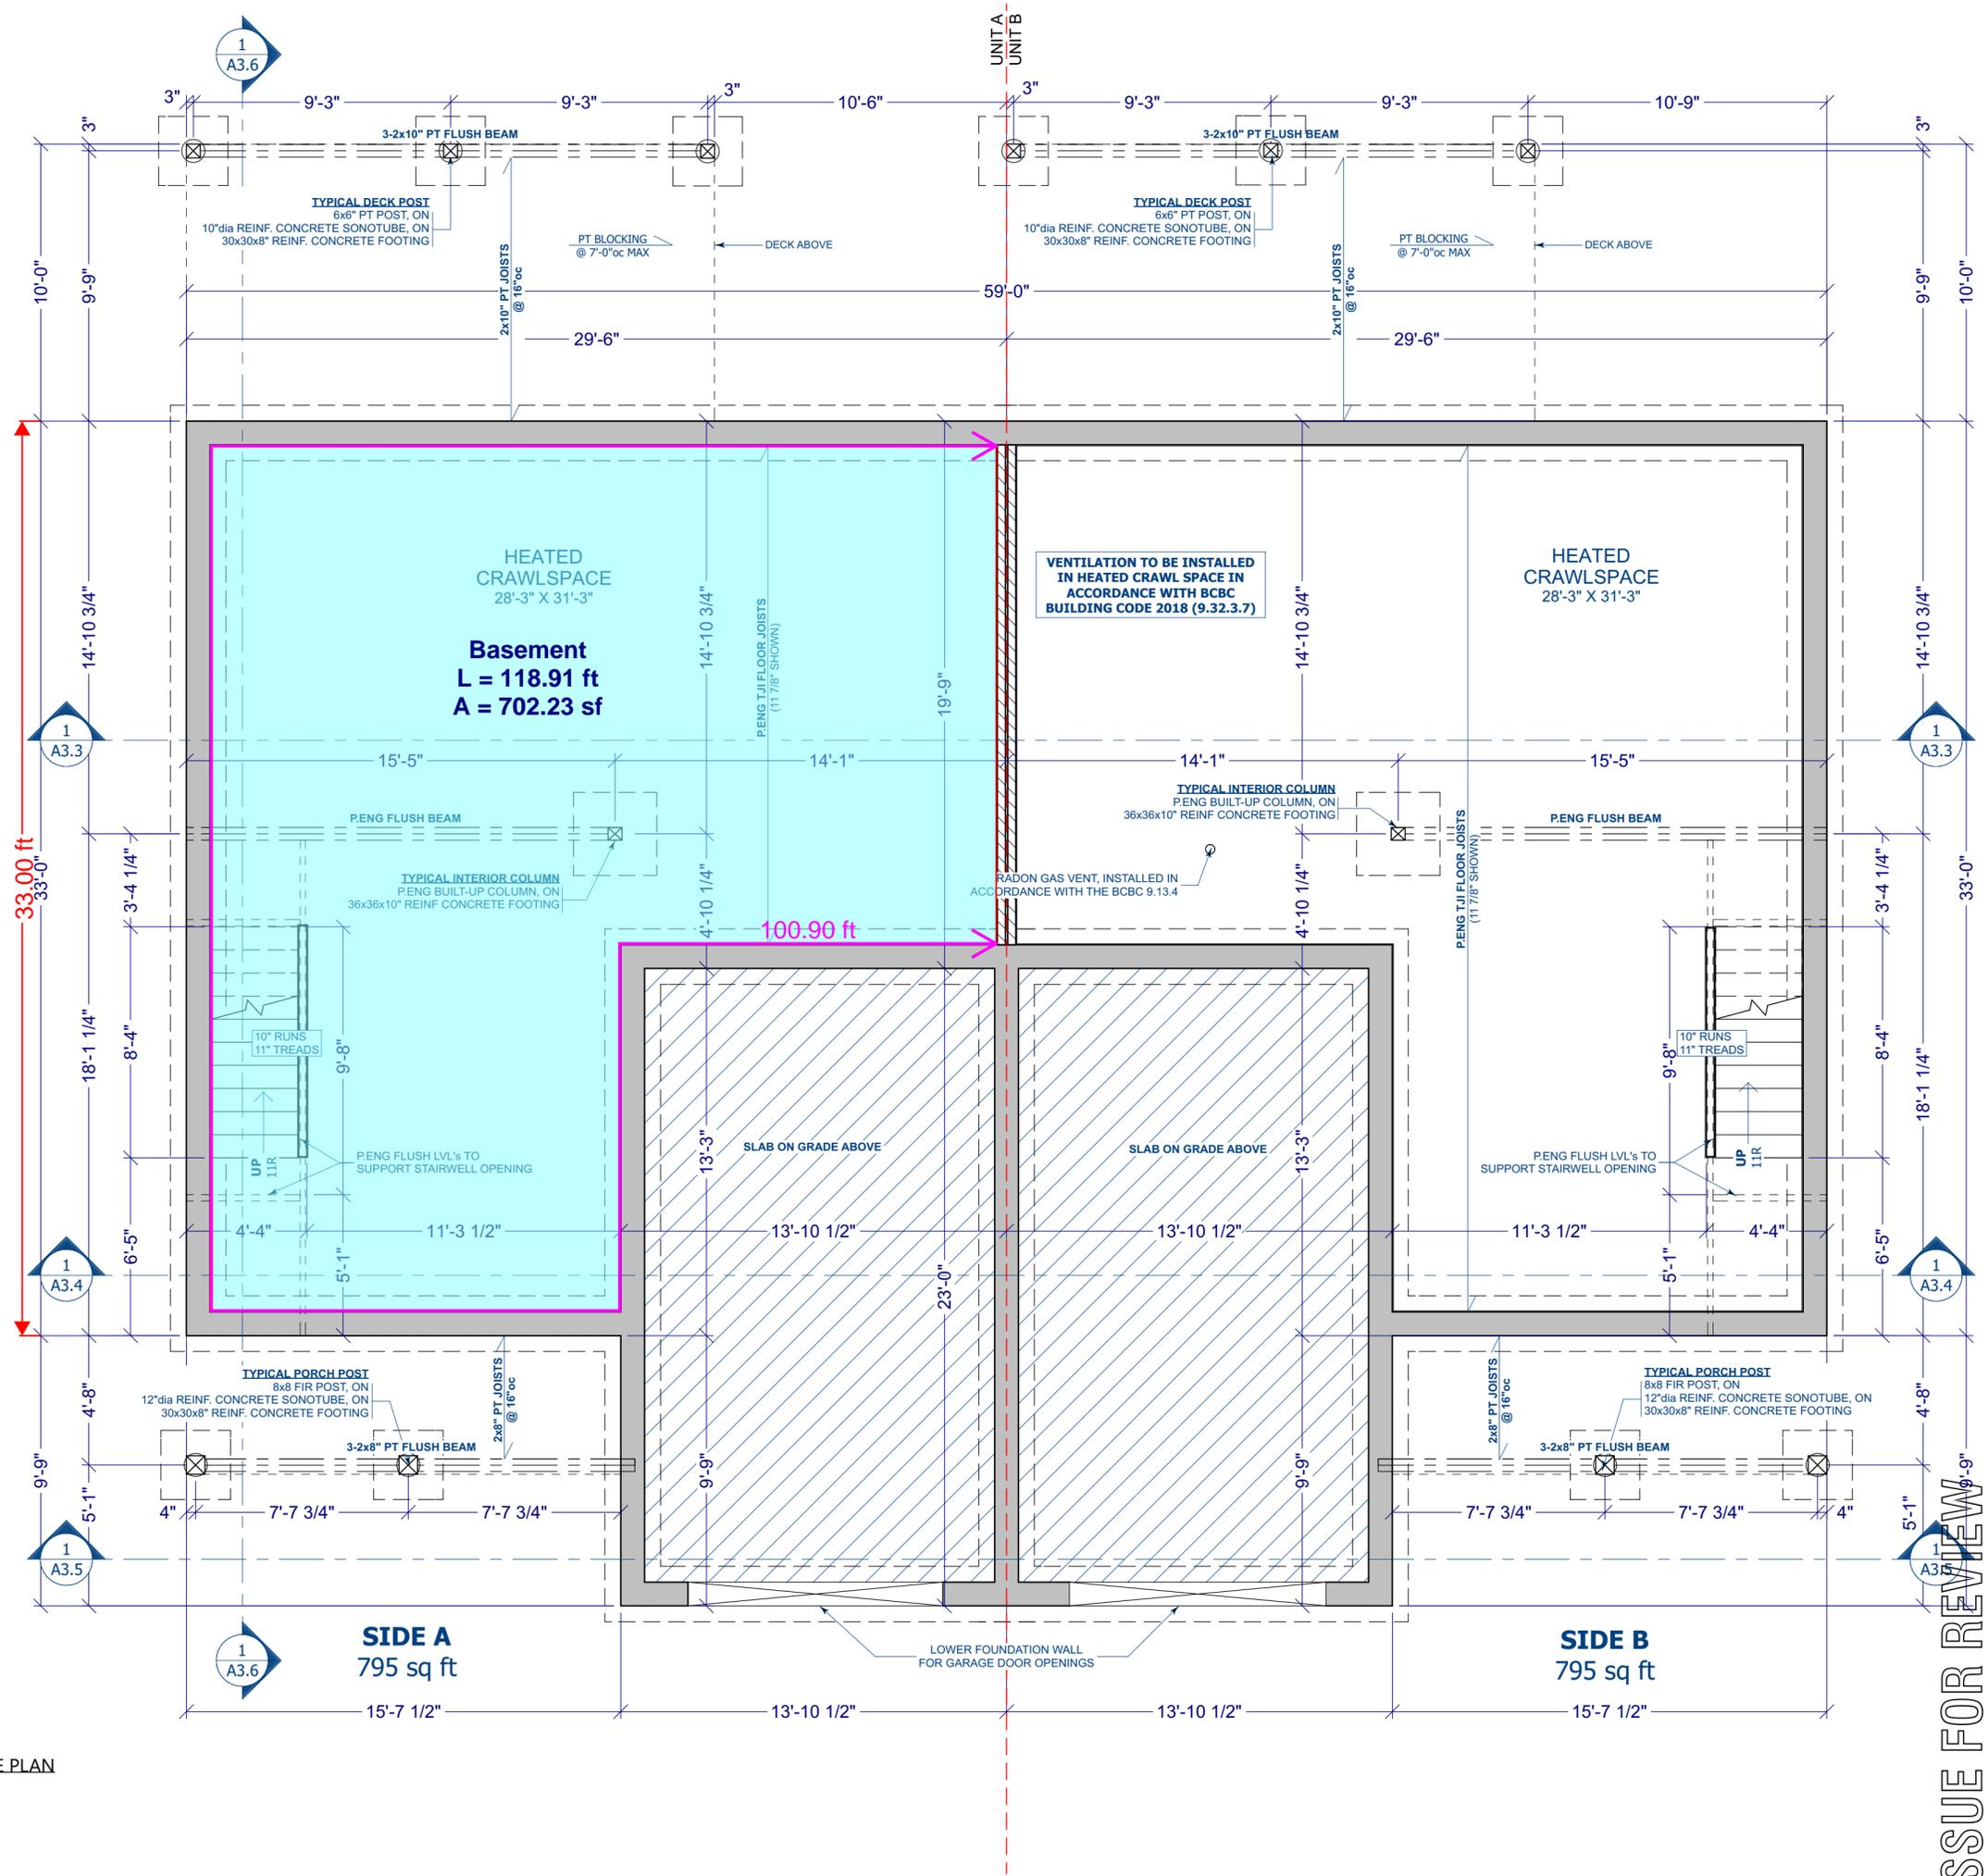

**CRAWLSPACE
AREA
1590 sq ft**

MECHANICAL & ELECTRICAL NOTES

1. VARIABLE SPEED FURNACE (1 PER SIDE)
2. POWER VENT HOT WATER TANK (1 PER SIDE)
3. AIR CONDITIONER (1 PER SIDE)
4. HRV (1 PER SIDE)
5. 200 AMP ELECTRICAL SERVICE (1 PER SIDE)
6. CONDUIT FOR FUTURE EV CHARGERS (GARAGES)
7. ELECTRIC FIREPLACE (LIVING ROOMS)
8. GAS BBQ OUTLET (REAR DECK)
9. IRRIGATION ROUGH-IN
10. WATERLINE TO FRIDGE
11. TV OUTLET (LIVING, LOFTS, MASTER BEDROOMS)
12. CAT 6 (OFFICES)

STRUCTURAL NOTE

SEE PENG I ENGINEERED DRAWINGS FOR ALL STRUCTURAL ELEMENTS OF DESIGN, INCLUDING FOUNDATION WALLS, BEAMS, COLUMNS, JOISTS, TRUSSES AND LINTELS. PAD FOOTING SIZES SUPPORTING ROOF LOAD TO BE CONFIRMED BY OTHER.



CRAWLSPACE PLAN

ISSUE FOR REVIEW

FLOODPLAIN CONSTRUCTION LEVEL: 996.8 m

GENERAL NOTES

- PLEASE READ CAREFULLY BEFORE BEGINNING PROJECT
1. WHILE EVERY ATTEMPT HAS BEEN MADE IN THE PREPARATION OF THIS PLAN TO AVOID MISTAKES, THE DESIGNER CANNOT GUARANTEE AGAINST HUMAN ERROR.
 2. THE DESIGNER IS UNABLE TO ACCEPT ANY LIABILITY FOR THE ACCURACY OR OVERALL INTEGRITY OF THESE DRAWINGS.
 3. DRAWINGS ARE NOT TO BE SCALED.
 4. ALL DIMENSIONS, DETAILS, AND NOTES TO BE REVIEWED AND CONFIRMED BY THE GENERAL CONTRACTOR BEFORE UNDERTAKING ANY WORK ON THE PROJECT. ANY DISCREPANCIES, ERRORS OR OMISSIONS TO BE REPORTED TO THE DESIGNER IMMEDIATELY BEFORE ORDERING MATERIALS OR COMMENCING CONSTRUCTION.
 5. DESIGNER IS NOT RESPONSIBLE FOR ERRORS AND OMISSIONS IN STRUCTURAL DESIGN. ALL STRUCTURAL SYSTEMS TO BE ENGINEERED BY OTHERS. STRUCTURAL LOCATIONS AND SIZES OF SONOTUBES, COLUMNS, FOOTINGS, AND BEAMS ARE A GUIDE ONLY; THEY MUST BE VERIFIED BY TRUSS / FLOOR MANUFACTURER BEFORE CONSTRUCTION BEGINS.
 6. ALL SITE DIMENSIONS AND MEASUREMENTS ARE TO BE GOVERNED AND APPROVED BY MUNICIPAL AUTHORITIES BEFORE STARTING CONSTRUCTION.
 7. ALL CONSTRUCTION TO COMPLY WITH CURRENT BUILDING CODE, REGULATIONS, RULES AND BYLAWS SET BY THE AUTHORITY HAVING JURISDICTION.
 8. ALL CONSTRUCTION TO COMPLY WITH INDUSTRY TRADE STANDARDS AND MANUFACTURER'S RECOMMENDATIONS WHERE THESE INSTRUCTIONS ARE MORE STRINGENT THAN THAT CONTAINED ON THE DRAWING. ALL MATERIALS AND ENGINEERED COMPONENTS TO BE INSTALLED TO MANUFACTURER'S SPECIFICATIONS AND AS PER ENGINEERING DRAWINGS.
 9. FOUNDATION AND FOOTING DESIGN ARE TYPICAL ONLY AND ASSUME STANDARD SOIL CONDITIONS AS OUTLINED IN THE BC BUILDING CODE, LATEST EDITION. IT IS THE RESPONSIBILITY OF THE OWNER / GENERAL CONTRACTOR TO CONFIRM SITE CONDITIONS AND PROVIDE ENGINEERING IF REQUIRED.
 10. GENERAL CONTRACTOR TO CONFIRM FOUNDATION WALLS MEET THE REQUIRED BACKFILL HEIGHTS. SPECIFIED WALLS AND GRADES TO BE ADJUSTED TO SUIT SITE CONDITIONS. EXTERIOR GRADES & ALL ELEMENTS AFFECTED BY FINAL GRADE ARE TO BE CONFIRMED PRIOR TO CONSTRUCTION BY OTHERS.
 11. ALL WOOD FRAMING TO BE SPF #2 OR BETTER. ANY LUMBER IN CONTACT WITH CONCRETE MUST BE PRESERVED WOOD FOUNDATION (PWF) MATERIAL.
 12. ALL LOADING & DRIFTING ARE TO BE DESIGNED BY OTHERS.
 13. PLUMBING, ELECTRICAL & HEATING BY CONTRACTOR TO CODE, LATEST EDITION.
 14. ROOF VENTS INSTALLED IN ACCORDANCE WITH THE BC BUILDING CODE 9.13.
 15. IN-FLOOR HEATED CONCRETE SYSTEM BY OTHERS. PROVIDIONS TO BE MADE FOR SOIL GAS CONTROL AS PER BC BUILDING CODE 9.13.4.
 17. STAIRS AND HANDRAILS INSTALLED IN ACCORDANCE WITH THE BC BUILDING CODE 9.8.
 18. DOOR AND WINDOW SIZES ARE APPROXIMATE AND MAY VARY BETWEEN MANUFACTURERS. ACTUAL SIZES AND ROUGH OPENINGS TO BE OBTAINED FROM SUPPLIER. ALL DOORS & WINDOWS MUST BE MARK COMPLIANT WHERE APPLICABLE AND IN ACCORDANCE WITH BC BUILDING CODE. DOORS BETWEEN HOUSE AND GARAGE TO HAVE SELF-CLOSING MECHANISM AND WEATHER STRIPPING. FIRE RATED DOORS / W SELF CLOSURES TO BE INSTALLED IN ALL FIRE RATED WALLS.
 19. INFORMATION ON THESE DRAWINGS ASSUME THE AREA OF DOORS AND WINDOWS DO NOT EXCEED THE MAXIMUM RATIO TO WALL AREA OF 25% UNLESS NOTED OTHERWISE.
 20. WALLS GREATER THAN 12'-0" IN HEIGHT TO COMPLY WITH THE LOCAL JURISDICTION'S GLUE FOR TALL WALLS (WHERE APPLICABLE) OR BE ENGINEERED.
 21. WORKING DRAWINGS ARE A GRAPHIC REPRESENTATION ONLY - ACTUAL PRODUCTS AND MATERIALS USED MAY VARY FROM THE DEPICTION ON DRAWING.
 22. ENGINEERS DRAWINGS AND/OR STAMP AS REQUIRED SHALL BE THE RESPONSIBILITY OF THE GENERAL CONTRACTOR AND/OR THE OWNER.
 23. ANYTHING NOT COVERED IN THE PLANS WILL BE OPEN FOR NEGOTIATION BETWEEN THE OWNER AND THE GENERAL CONTRACTOR.

THE INFORMATION CONTAINED ON THIS DRAWING HAS BEEN PREPARED FOR THE SOLE PURPOSE OF THE PROJECT DESCRIBED HEREIN AND FOR THE SOLE BENEFIT OF THE OWNER. USE OF THIS INFORMATION FOR ANY PURPOSE OTHER THAN THE PROJECT DESCRIBED HEREIN IS AT THE SOLE RISK OF THE USER. ANY UNAUTHORIZED USE OF THIS INFORMATION WILL BE CONSIDERED A BREACH OF COPYRIGHT AND MAY BE PUNISHED AS SUCH.



T 250 489 9022 | E kin@timbershbd.com


GRIFFITHS DUPLEX

PROJECT ADDRESS: 980 HAND STREET FERNIE, BC
 LEGAL ADDRESS: LOT 1/A, PLAN NEP15240, DL 5455, KOOTENAY DISTRICT PID: 009-503-340

MAIN FLOOR PLAN

No.	REVISION	DATE	BY
1	ISSUE FOR REVIEW	11 MAR	KD

DATE: 11-MAR-24
 SCALE: 1/4" = 1'-0"
A2.2

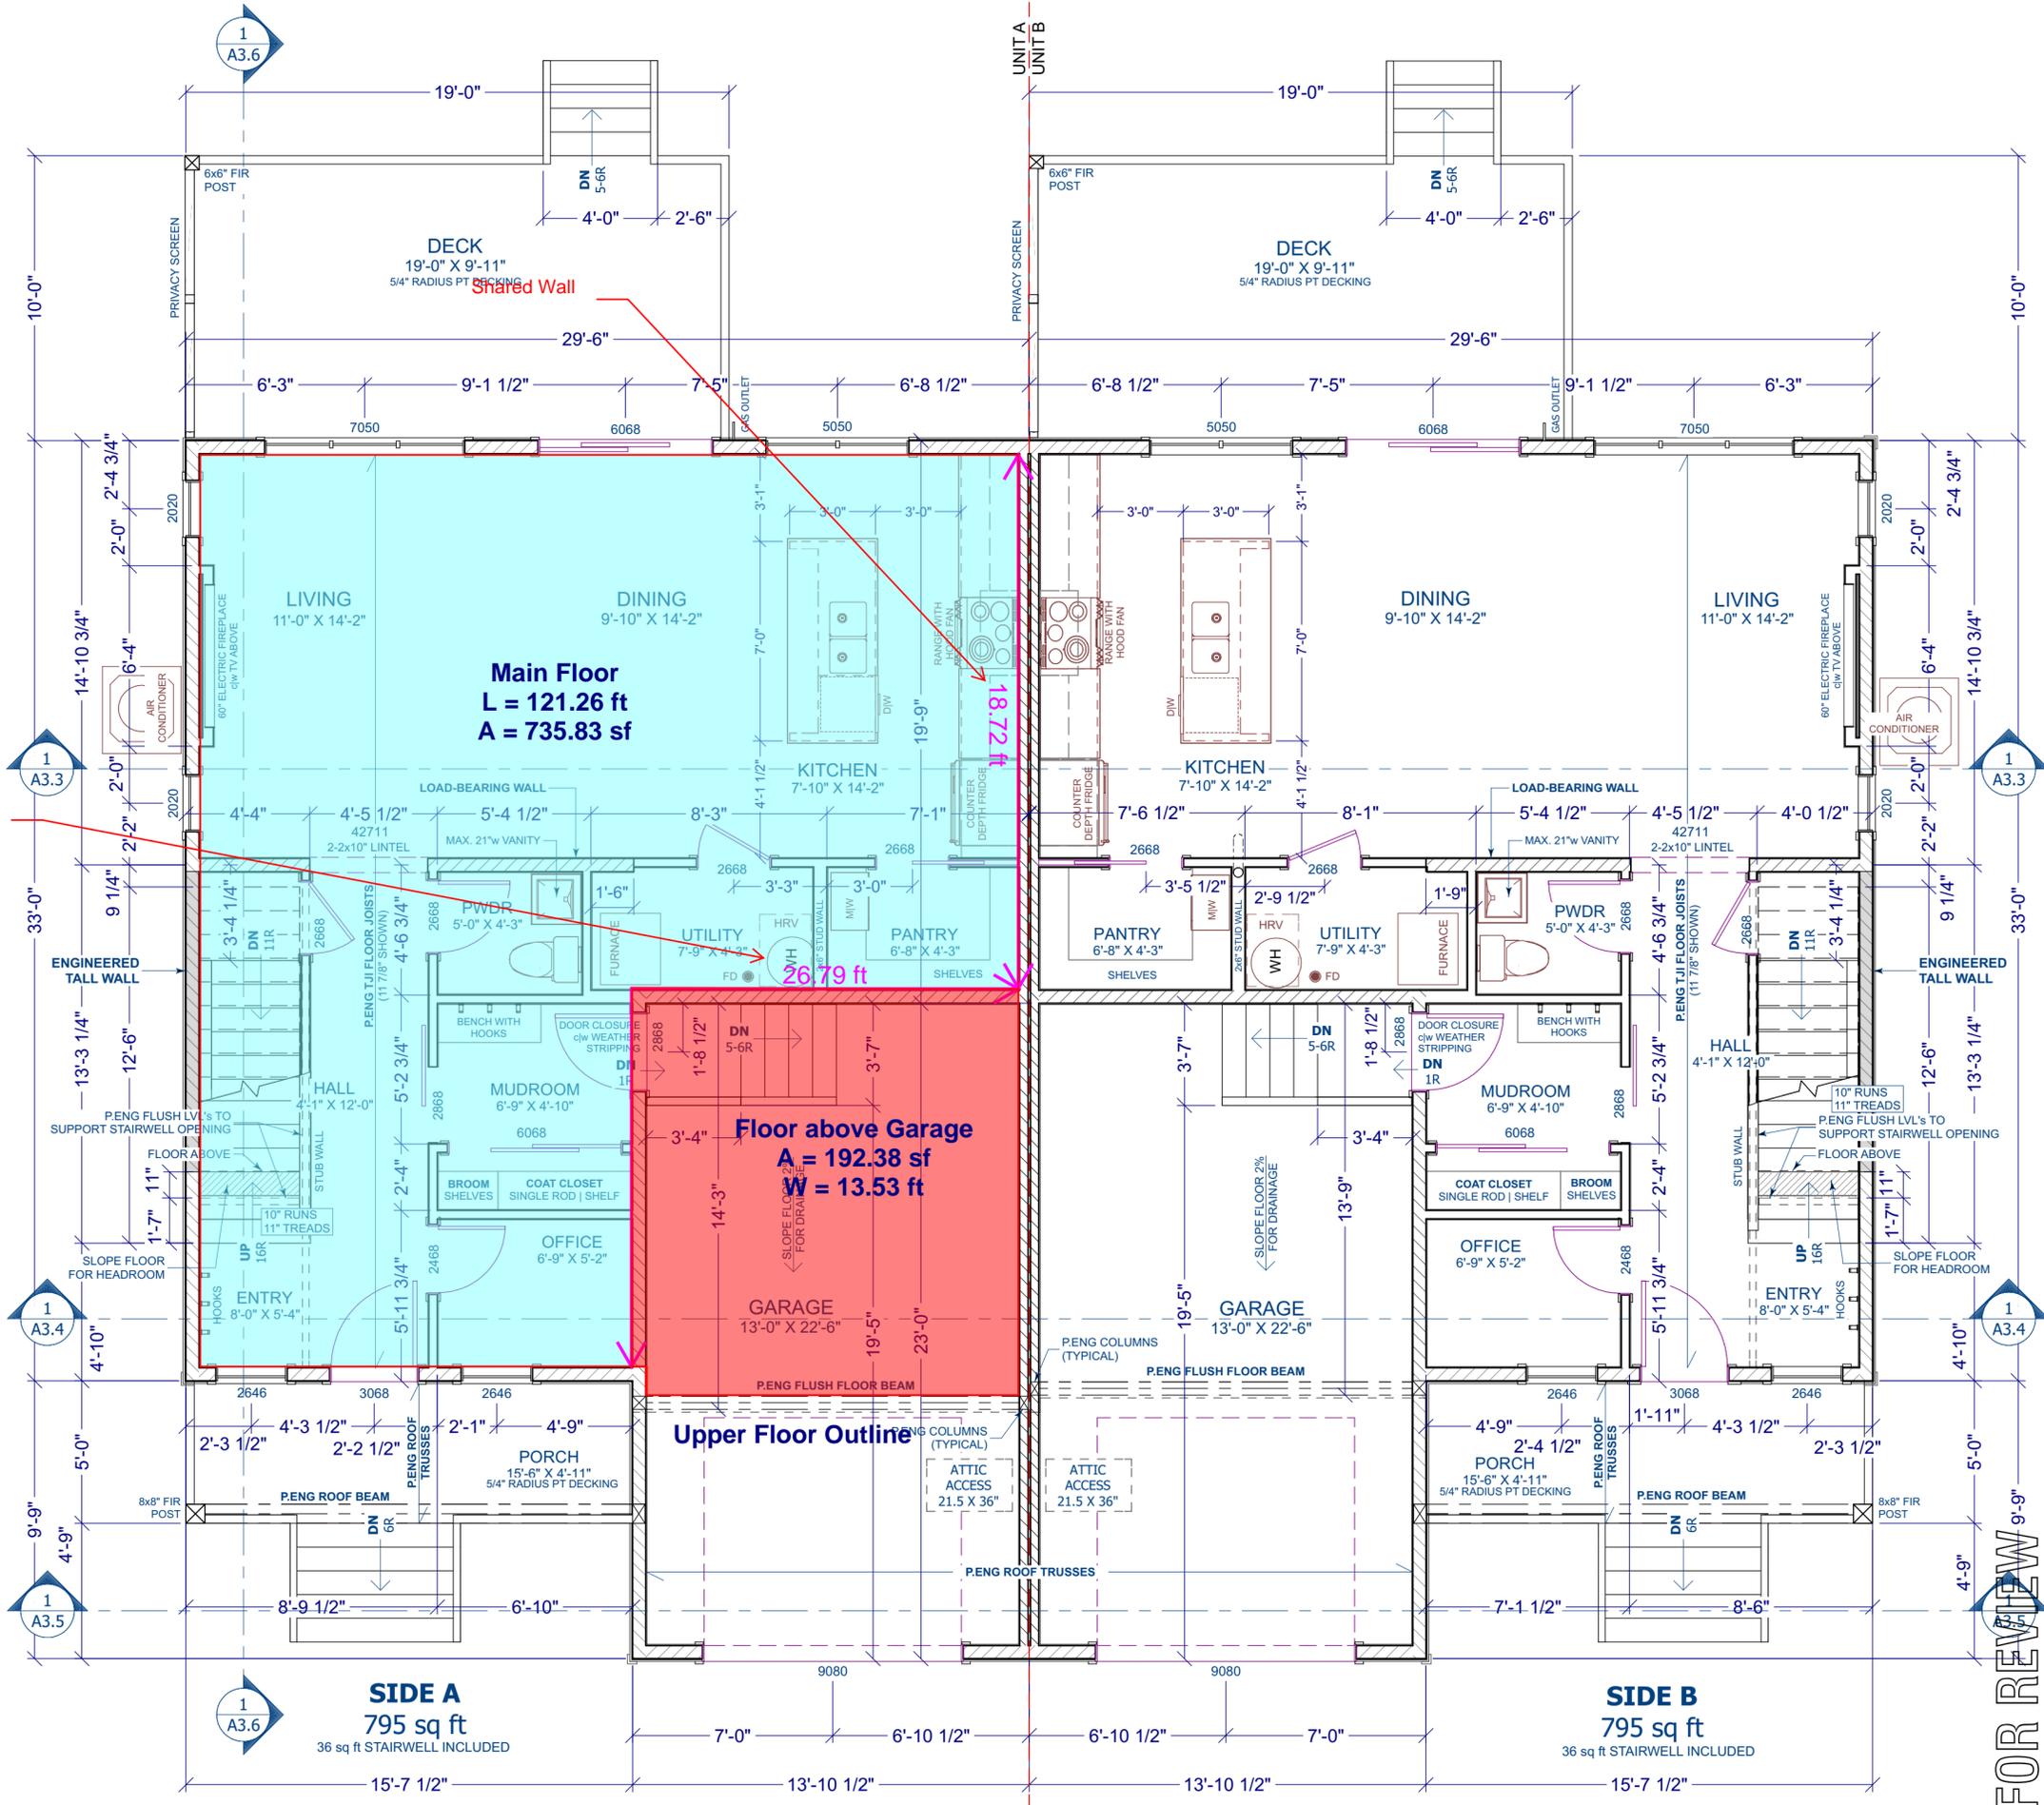

- MECHANICAL & ELECTRICAL NOTES**
1. VARIABLE SPEED FURNACE (1 PER SIDE)
 2. POWER VENT HOT WATER TANK (1 PER SIDE)
 3. AIR CONDITIONER (1 PER SIDE)
 4. HRV (1 PER SIDE)
 5. 200 AMP ELECTRICAL SERVICE (1 PER SIDE)
 6. CONDUIT FOR FUTURE EV CHARGERS (GARAGES)
 7. ELECTRIC FIREPLACE (LIVING ROOMS)
 8. GAS BBQ OUTLET (REAR DECK)
 9. IRRIGATION ROUGH-IN
 10. WATERLINE TO FRIDGE
 11. TV OUTLET (LIVING, LOFTS, MASTER BEDROOMS)
 12. CAT 6 (OFFICES)

STRUCTURAL NOTE

SEE P.ENG | ENGINEERED DRAWINGS FOR ALL STRUCTURAL ELEMENTS OF DESIGN, INCLUDING FOUNDATION WALLS, BEAMS, COLUMNS, JOISTS, TRUSSES AND LINTELS. PAD FOOTING SIZES SUPPORTING ROOF LOAD TO BE CONFIRMED BY OTHER.

- WINDOW NOTES**
1. INSTALL WINDOWS TO MATCH T/O EXTERIOR MAN DOORS. SECOND FLOOR WINDOWS INSTALLED ~83" aff
 2. WINDOW SIZES ARE APPROXIMATE. REFER TO WINDOW MANUFACTURER SUPPLIED R.O. SIZES
 3. ALL WINDOW & DOOR LINTELS TO BE SIZED BY P.ENG

ISSUE FOR REVIEW

FLOODPLAIN CONSTRUCTION LEVEL: 996.8 m

GENERAL NOTES

- PLEASE READ CAREFULLY BEFORE BEGINNING PROJECT
1. WHILE EVERY ATTEMPT HAS BEEN MADE IN THE PREPARATION OF THIS PLAN TO AVOID MISTAKES, THE DESIGNER CANNOT GUARANTEE AGAINST HUMAN ERROR.
 2. THE DESIGNER IS UNABLE TO ACCEPT ANY LIABILITY FOR THE ACCURACY OR OVERALL INTEGRITY OF THESE DRAWINGS.
 3. DRAWINGS ARE NOT TO BE SCALED.
 4. ALL DRAWINGS, DIMENSIONS, DETAILS, AND NOTES TO BE REVIEWED AND CONFIRMED BY THE GENERAL CONTRACTOR BEFORE UNDERTAKING ANY WORK ON THE PROJECT. ANY DISCREPANCIES, ERRORS OR OMISSIONS TO BE REPORTED TO THE DESIGNER IMMEDIATELY BEFORE ORDERING MATERIALS OR COMMENCING CONSTRUCTION.
 5. DESIGNER IS NOT RESPONSIBLE FOR ERRORS AND OMISSIONS IN STRUCTURAL DESIGN. ALL STRUCTURAL SYSTEMS TO BE ENGINEERED BY OTHERS. STRUCTURAL LOCATIONS AND SIZES OF SONOTUBES, COLUMNS, FOOTINGS, AND BEAMS ARE A GUIDE ONLY; THEY MUST BE VERIFIED BY TRUSS / FLOOR MANUFACTURER BEFORE CONSTRUCTION BEGINS.
 6. ALL SITE DIMENSIONS AND MEASUREMENTS ARE TO BE GOVERNED AND APPROVED BY MUNICIPAL AUTHORITIES BEFORE STARTING CONSTRUCTION.
 7. ALL CONSTRUCTION TO COMPLY WITH CURRENT BUILDING CODE, REGULATIONS, RULES AND BYLAWS SET BY THE AUTHORITY HAVING JURISDICTION.
 8. ALL CONSTRUCTION TO COMPLY WITH INDUSTRY TRADE STANDARDS AND MANUFACTURER'S RECOMMENDATIONS WHERE THESE INSTRUCTIONS AND RECOMMENDATIONS ARE MORE STRINGENT THAN THAT CONTAINED ON THE DRAWING. ALL MATERIALS AND ENGINEERED COMPONENTS TO BE INSTALLED TO MANUFACTURER'S SPECIFICATIONS AND AS PER ENGINEERING DRAWINGS.
 9. FOUNDATION AND FOOTING DESIGN ARE TYPICAL ONLY AND ASSUME STANDARD SOIL CONDITIONS AS OUTLINED IN THE BC BUILDING CODE, LATEST EDITION. IT IS THE RESPONSIBILITY OF THE OWNER / GENERAL CONTRACTOR TO CONFIRM SITE CONDITIONS AND PROVIDE ENGINEERING IF REQUIRED.
 10. GENERAL CONTRACTOR TO CONFIRM FOUNDATION WALLS MEET THE REQUIRED BACKFILL HEIGHTS, SPECIFIED WALLS AND GRADES TO BE ADJUSTED TO SUIT SITE CONDITIONS. EXTERIOR GRADE & ALL ELEMENTS AFFECTED BY FINAL GRADE ARE TO BE CONFIRMED PRIOR TO CONSTRUCTION (BY OTHER).
 11. ALL WOOD FRAMING TO BE SPF #2 OR BETTER. ANY LUMBER IN CONTACT WITH CONCRETE MUST BE TREATED WOOD FOUNDATION (PWF) MATERIAL.
 12. ALL LOADING & DRIFTING ARE TO BE DESIGNED BY OTHERS.
 13. PLUMBING, ELECTRICAL & HEATING BY CONTRACTOR TO CODE, LATEST EDITION.
 14. ROOF VENTS INSTALLED IN ACCORDANCE WITH THE BC BUILDING CODE 9.19.1.
 15. IN-FLOOR HEATED CONCRETE SYSTEM BY OTHERS CONTROL AS PER BC BUILDING CODE 9.13.4.
 17. STAIRS AND HANDRAILS INSTALLED IN ACCORDANCE WITH THE BC BUILDING CODE 9.8.
 18. DOOR AND WINDOW SIZES ARE APPROXIMATE AND MAY VARY BETWEEN MANUFACTURERS. ACTUAL SIZES AND ROUGH OPENINGS TO BE OBTAINED FROM SUPPLIER. ALL DOORS & WINDOWS DO NOT EXCEED THE MAXIMUM RATIO TO WALL AREA OF 25% UNLESS NOTED OTHERWISE.
 19. INFORMATION ON THESE DRAWINGS ASSUME THE AREA OF DOORS AND WINDOWS DO NOT EXCEED THE MAXIMUM RATIO TO WALL AREA OF 25% UNLESS NOTED OTHERWISE.
 20. WALLS GREATER THAN 12'-0" IN HEIGHT TO COMPLY WITH THE LOCAL JURISDICTION'S GLUE FOR TALL WALLS (WHERE APPLICABLE) OR BE ENGINEERED.
 21. WORKING DRAWINGS ARE A GRAPHIC REPRESENTATION ONLY - ACTUAL PRODUCTS AND MATERIALS USED MAY VARY FROM THE DEPICTION ON DRAWING.
 22. ENGINEERS DRAWINGS AND/OR STAMP AS REQUIRED SHALL BE THE RESPONSIBILITY OF THE GENERAL CONTRACTOR AND/OR THE OWNER.
 23. ANYTHING NOT COVERED IN THE PLANS WILL BE OPEN FOR NEGOTIATION BETWEEN THE OWNER AND THE GENERAL CONTRACTOR.

THE INFORMATION CONTAINED ON THIS DRAWING HAS BEEN PREPARED FOR THE SOLE PURPOSE OF THE PROJECT DESCRIBED HEREIN AND FOR THE SOLE BENEFIT OF THE OWNER. USE OF THIS INFORMATION FOR ANY PURPOSE OTHER THAN THE PROJECT DESCRIBED HEREIN IS AT THE SOLE RISK OF THE USER. ANY UNAUTHORIZED USE OF THIS INFORMATION WILL BE CONSIDERED A BREACH OF COPYRIGHT AND MAY BE PUNISHED AS SUCH.



T 250 489 9022 | E kim@timbershbd.com


GRIFFITHS DUPLEX

PROJECT ADDRESS: 980 HAND STREET FERNIE, BC
LEGAL ADDRESS: LOT 1/A, PLAN NEP15240, DL 5455, KOOTENAY DISTRICT PID: 009-503-340

SECOND FLOOR PLAN

No.	REVISION	DATE	BY
1	ISSUE FOR REVIEW	11 MAR	KD

DATE: 11-MAR-24
SCALE: 1/4" = 1'-0"
A2.3

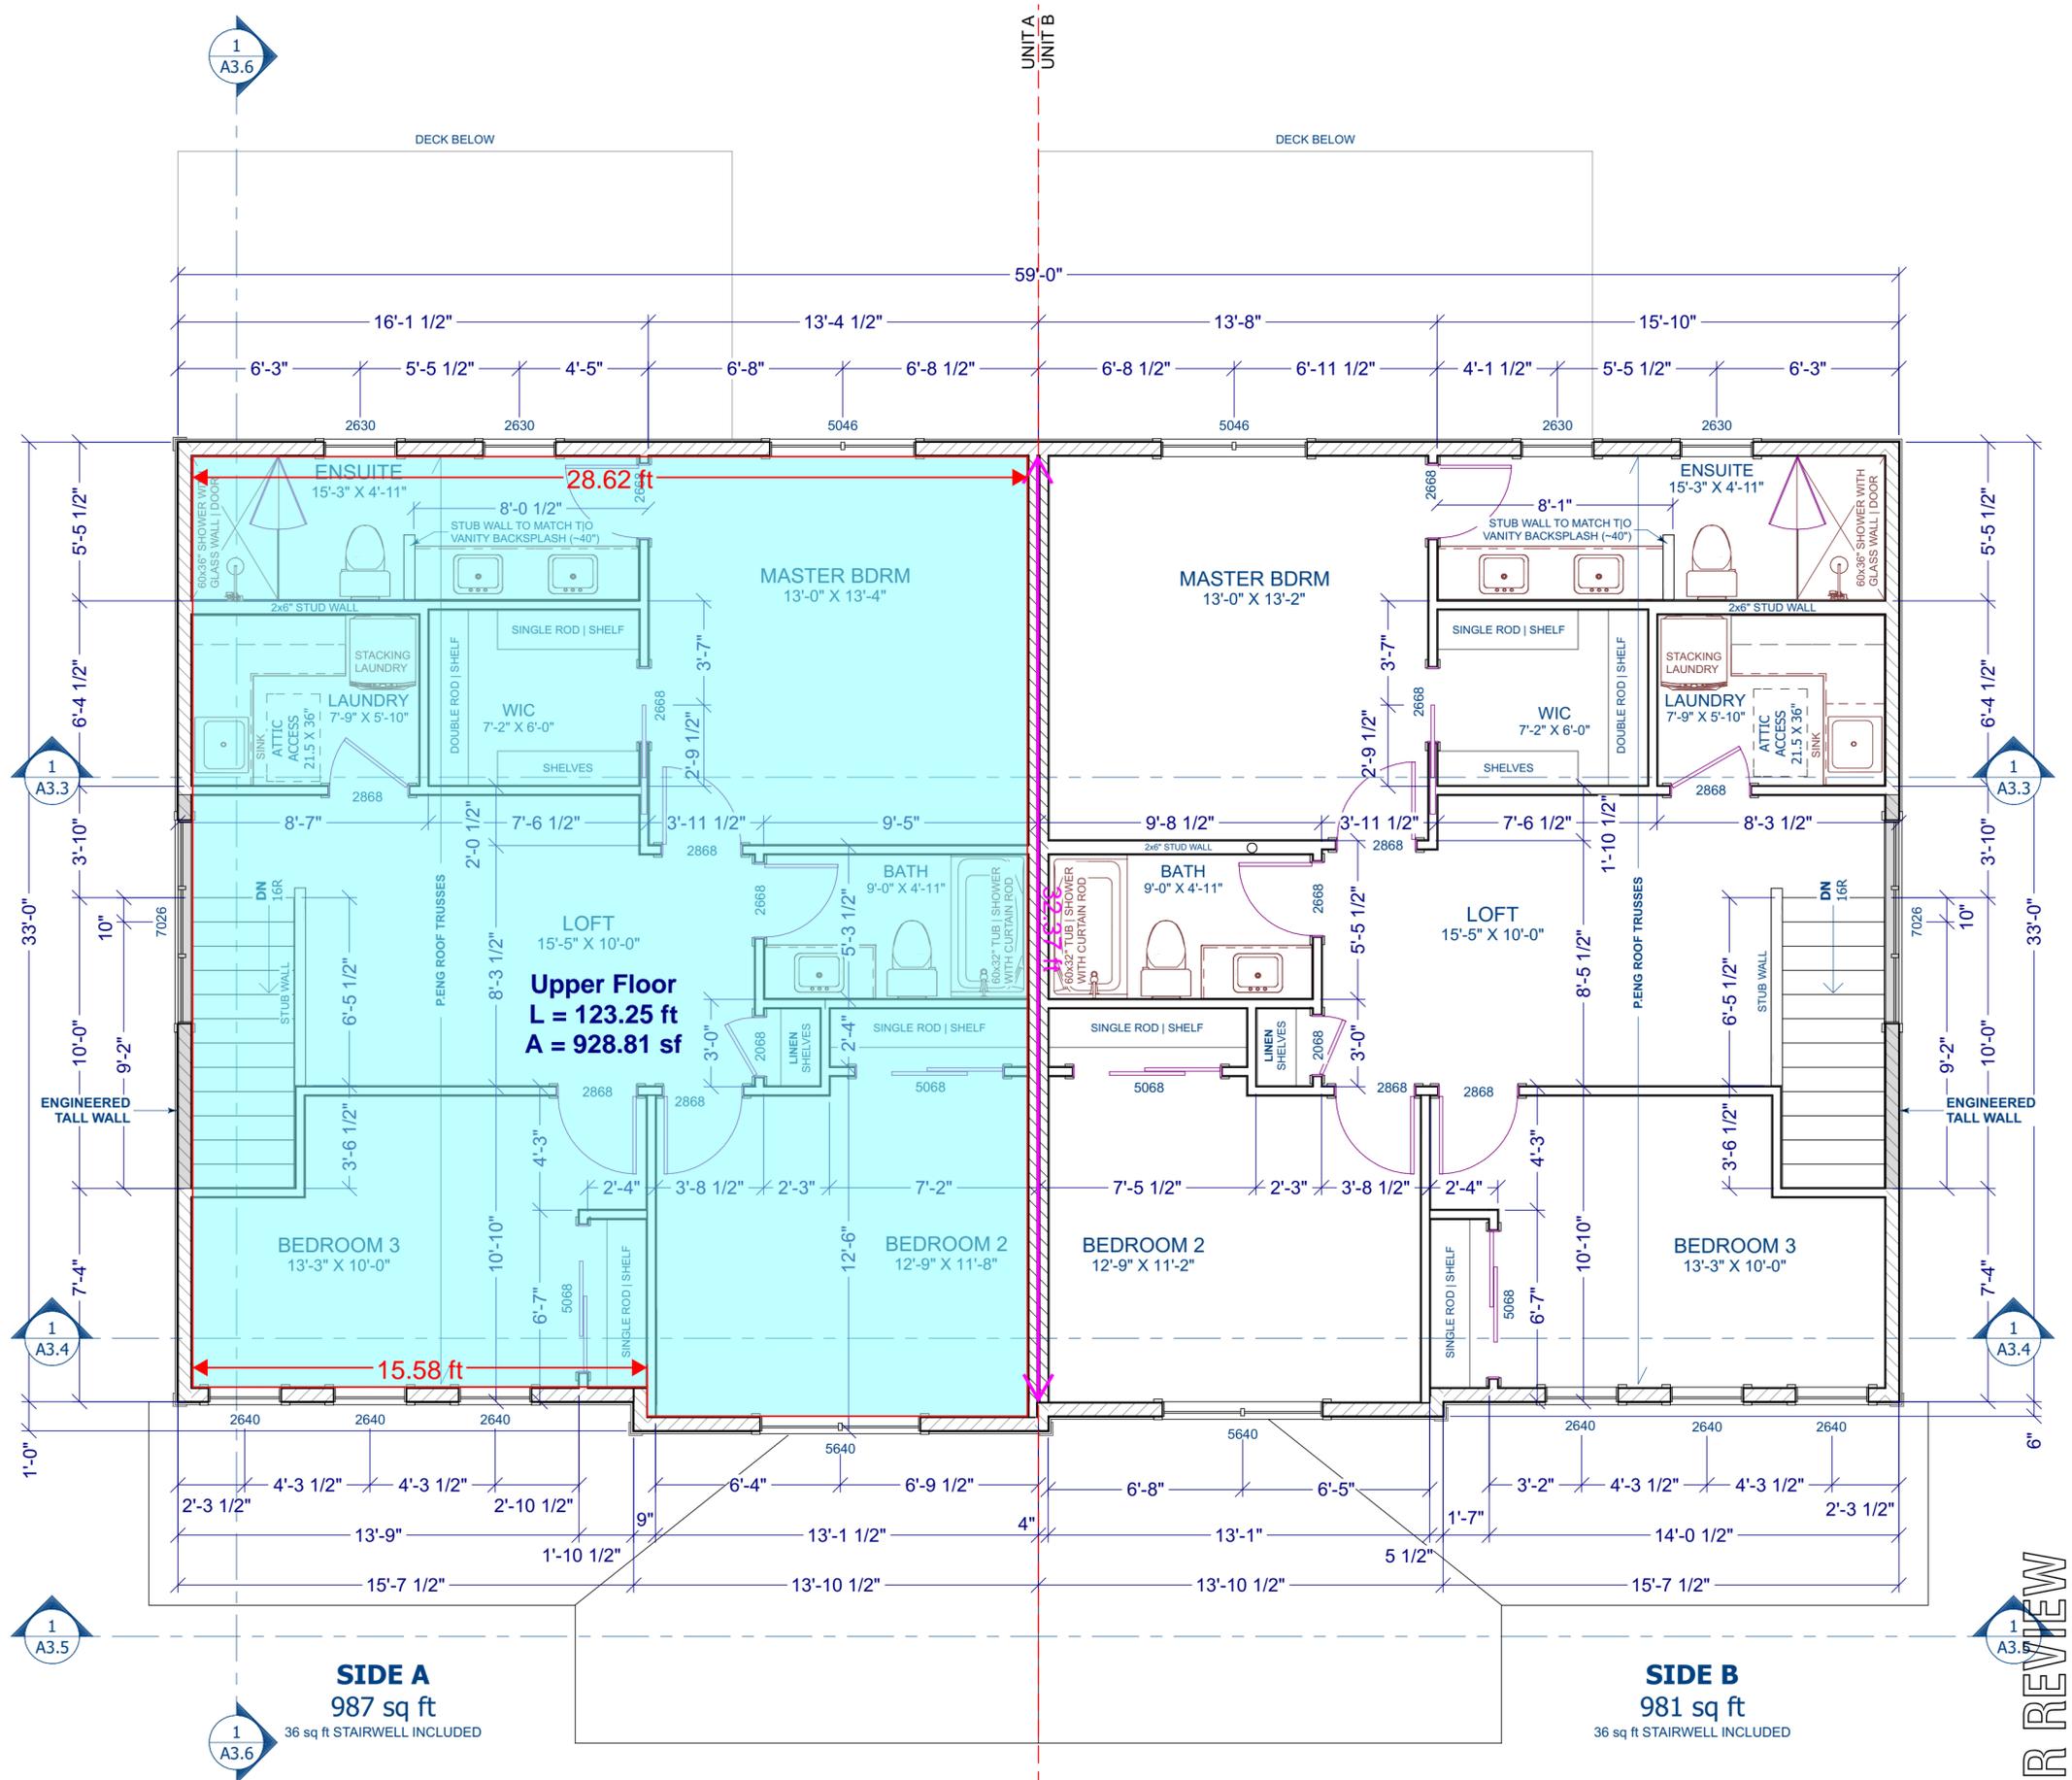

LIVING AREA
1968 sq ft
36 sq ft STAIRWELLS INCLUDED

- MECHANICAL & ELECTRICAL NOTES**
1. VARIABLE SPEED FURNACE (1 PER SIDE)
 2. POWER VENT HOT WATER TANK (1 PER SIDE)
 3. AIR CONDITIONER (1 PER SIDE)
 4. HRV (1 PER SIDE)
 5. 200 AMP ELECTRICAL SERVICE (1 PER SIDE)
 6. CONDUIT FOR FUTURE EV CHARGERS (GARAGES)
 7. ELECTRIC FIREPLACE (LIVING ROOMS)
 8. GAS BBQ OUTLET (REAR DECK)
 9. IRRIGATION ROUGH-IN
 10. WATERLINE TO FRIDGE
 11. TV OUTLET (LIVING, LOFTS, MASTER BEDROOMS)
 12. CAT 6 (OFFICES)

STRUCTURAL NOTE
SEE P.ENG | ENGINEERED DRAWINGS FOR ALL STRUCTURAL ELEMENTS OF DESIGN, INCLUDING FOUNDATION WALLS, BEAMS, COLUMNS, JOISTS, TRUSSES AND LINTELS. PAD FOOTING SIZES SUPPORTING ROOF LOAD TO BE CONFIRMED BY OTHER.

- WINDOW NOTES**
1. INSTALL WINDOWS TO MATCH T/O EXTERIOR MAN DOORS. SECOND FLOOR WINDOWS INSTALLED ~83" aff
 2. WINDOW SIZES ARE APPROXIMATE. REFER TO WINDOW MANUFACTURER SUPPLIED R.O. SIZES
 3. ALL WINDOW & DOOR LINTELS TO BE SIZED BY P.ENG

SIDE A
987 sq ft
36 sq ft STAIRWELL INCLUDED

SIDE B
981 sq ft
36 sq ft STAIRWELL INCLUDED

ISSUE FOR REVIEW

GENERAL NOTES

- PLEASE READ CAREFULLY BEFORE BEGINNING PROJECT
1. WHILE EVERY ATTEMPT HAS BEEN MADE IN THE PREPARATION OF THIS PLAN TO AVOID MISTAKES, THE DESIGNER CANNOT GUARANTEE AGAINST HUMAN ERROR.
 2. THE DESIGNER IS UNABLE TO ACCEPT ANY LIABILITY FOR THE ACCURACY OR OVERALL INTEGRITY OF THESE DRAWINGS.
 3. DRAWINGS ARE NOT TO BE SCALED.
 4. ALL DRAWINGS, DIMENSIONS, DETAILS, AND NOTES TO BE REVIEWED AND CONFIRMED BY THE GENERAL CONTRACTOR BEFORE UNDERTAKING ANY WORK ON THE PROJECT. ANY DISCREPANCIES, ERRORS OR OMISSIONS TO BE REPORTED TO THE DESIGNER IMMEDIATELY BEFORE ORDERING MATERIALS OR COMMENCING CONSTRUCTION.
 5. DESIGNER IS NOT RESPONSIBLE FOR ERRORS AND OMISSIONS IN STRUCTURAL DESIGN. ALL STRUCTURAL SYSTEMS TO BE ENGINEERED BY OTHERS. STRUCTURAL LOCATIONS AND SIZES OF SONOTUBES, COLUMNS, FOOTINGS, AND BEAMS ARE A GUIDE ONLY; THEY MUST BE VERIFIED BY TRUSS / FLOOR MANUFACTURER BEFORE CONSTRUCTION BEGINS.
 6. ALL SITE DIMENSIONS AND MEASUREMENTS ARE TO BE GOVERNED AND APPROVED BY MUNICIPAL AUTHORITIES BEFORE STARTING CONSTRUCTION.
 7. ALL CONSTRUCTION TO COMPLY WITH CURRENT BUILDING CODE, REGULATIONS, RULES AND BYLAWS SET BY THE AUTHORITY HAVING JURISDICTION.
 8. ALL CONSTRUCTION TO COMPLY WITH INDUSTRY TRADE STANDARDS AND MANUFACTURER'S RECOMMENDATIONS WHERE THOSE INSTRUCTIONS AND RECOMMENDATIONS ARE MORE STRINGENT THAN THAT CONTAINED ON THE DRAWING. ALL MATERIALS AND ENGINEERED COMPONENTS TO BE INSTALLED TO MANUFACTURER'S SPECIFICATIONS AND AS PER ENGINEERED DRAWINGS.
 9. FOUNDATION AND FOOTING DESIGN ARE TYPICAL ONLY AND ASSUME STANDARD SOIL CONDITIONS AS OUTLINED IN THE BC BUILDING CODE, LATEST EDITION. IT IS THE RESPONSIBILITY OF THE OWNER | GENERAL CONTRACTOR TO CONFIRM SITE CONDITIONS AND PROVIDE ENGINEERING IF REQUIRED.
 10. GENERAL CONTRACTOR TO CONFIRM FOUNDATION WALLS MEET THE REQUIRED BACKFILL HEIGHTS, SPECIFIED WALLS AND GRADES TO BE ADJUSTED TO SUIT SITE CONDITIONS. EXTERIOR GRADES & ALL ELEMENTS AFFECTED BY FINAL GRADE ARE TO BE CONFIRMED PRIOR TO CONSTRUCTION (BY OTHER).
 11. ALL WOOD FRAMING TO BE SPF #2 OR BETTER. ANY LUMBER IN CONTACT WITH CONCRETE MUST BE "PRESERVED WOOD FOUNDATION" (PW) MATERIAL.
 12. ALL LOADING & DRIFTING ARE TO BE DESIGNED BY OTHERS.
 13. PLUMBING, ELECTRICAL & HEATING BY CONTRACTOR TO CODE, LATEST EDITION.
 14. ROOF VENTS INSTALLED IN ACCORDANCE WITH THE BC BUILDING CODE 9.13.1.
 15. IN-FLOOR HEATED CONCRETE SYSTEM BY OTHERS. PROVISIONS TO BE MADE FOR SOIL GAS CONTROL AS PER BC BUILDING CODE 9.13.4.
 17. STAIRS AND HANDRAILS INSTALLED IN ACCORDANCE WITH THE BC BUILDING CODE 9.8.
 18. DOOR AND WINDOW SIZES ARE APPROXIMATE AND MAY VARY BETWEEN MANUFACTURERS. ACTUAL SIZES AND ROUGH OPENINGS TO BE OBTAINED FROM SUPPLIER. ALL DOORS & WINDOWS MUST BE MARK COMPLIANT WHERE APPLICABLE AND IN ACCORDANCE WITH BC BUILDING CODE. DOORS BETWEEN HOUSE AND GARAGE TO HAVE SELF-CLOSING MECHANISM AND WEATHER STRIPPING. FIRE RATED DOORS / w SELF CLOSURES TO BE INSTALLED IN ALL FIRE RATED WALLS.
 19. INFORMATION ON THESE DRAWINGS ASSUME THE AREA OF DOORS AND WINDOWS DO NOT EXCEED THE MAXIMUM RATIO TO WALL AREA OF 25% UNLESS NOTED OTHERWISE.
 20. WALLS GREATER THAN 12'-0" IN HEIGHT TO COMPLY WITH THE LOCAL JURISDICTION'S GLUE FOR TALL WALLS (WHERE APPLICABLE) OR BE ENGINEERED.
 21. WORKING DRAWINGS ARE A GRAPHIC REPRESENTATION ONLY - ACTUAL PRODUCTS AND MATERIALS USED MAY VARY FROM THE DEPICTION ON DRAWING.
 22. ENGINEERS DRAWINGS AND/OR STAMP AS REQUIRED SHALL BE THE RESPONSIBILITY OF THE GENERAL CONTRACTOR AND/OR THE OWNER.
 23. ANYTHING NOT COVERED IN THE PLANS WILL BE OPEN FOR NEGOTIATION BETWEEN THE OWNER AND THE GENERAL CONTRACTOR.

THE INFORMATION CONTAINED ON THIS DRAWING HAS BEEN PREPARED FOR THE SOLE PURPOSE OF THE PROJECT DESCRIBED HEREIN AND FOR THE SOLE BENEFIT OF THE OWNER. USE OF THIS INFORMATION FOR ANY PURPOSE OTHER THAN THE PROJECT DESCRIBED HEREIN IS AT THE SOLE RISK OF THE USER. ANY UNAUTHORIZED USE OF THIS INFORMATION WILL BE CONSIDERED A BREACH OF COPYRIGHT AND MAY BE PURSUED AS SUCH.



TIMBERS
home + building design
T 250 489 9022 | E kin@timberhbd.com


GRIFFITHS DUPLEX

PROJECT ADDRESS
980 HAND STREET
FERNIE, BC

LEGAL ADDRESS
LOT 1/A, PLAN NEP15240,
DL 5455, KOOTENAY DISTRICT
PID: 009-503-340

ISSUE FOR REVIEW

7			
6			
5			
4			
3			
2			
1	ISSUE FOR REVIEW	11 MAR	KD
No.	REVISION	DATE	BY
DATE	PAGE No.		
11-MAR-24			
SCALE	A2.4		
1/4" = 1'-0"			

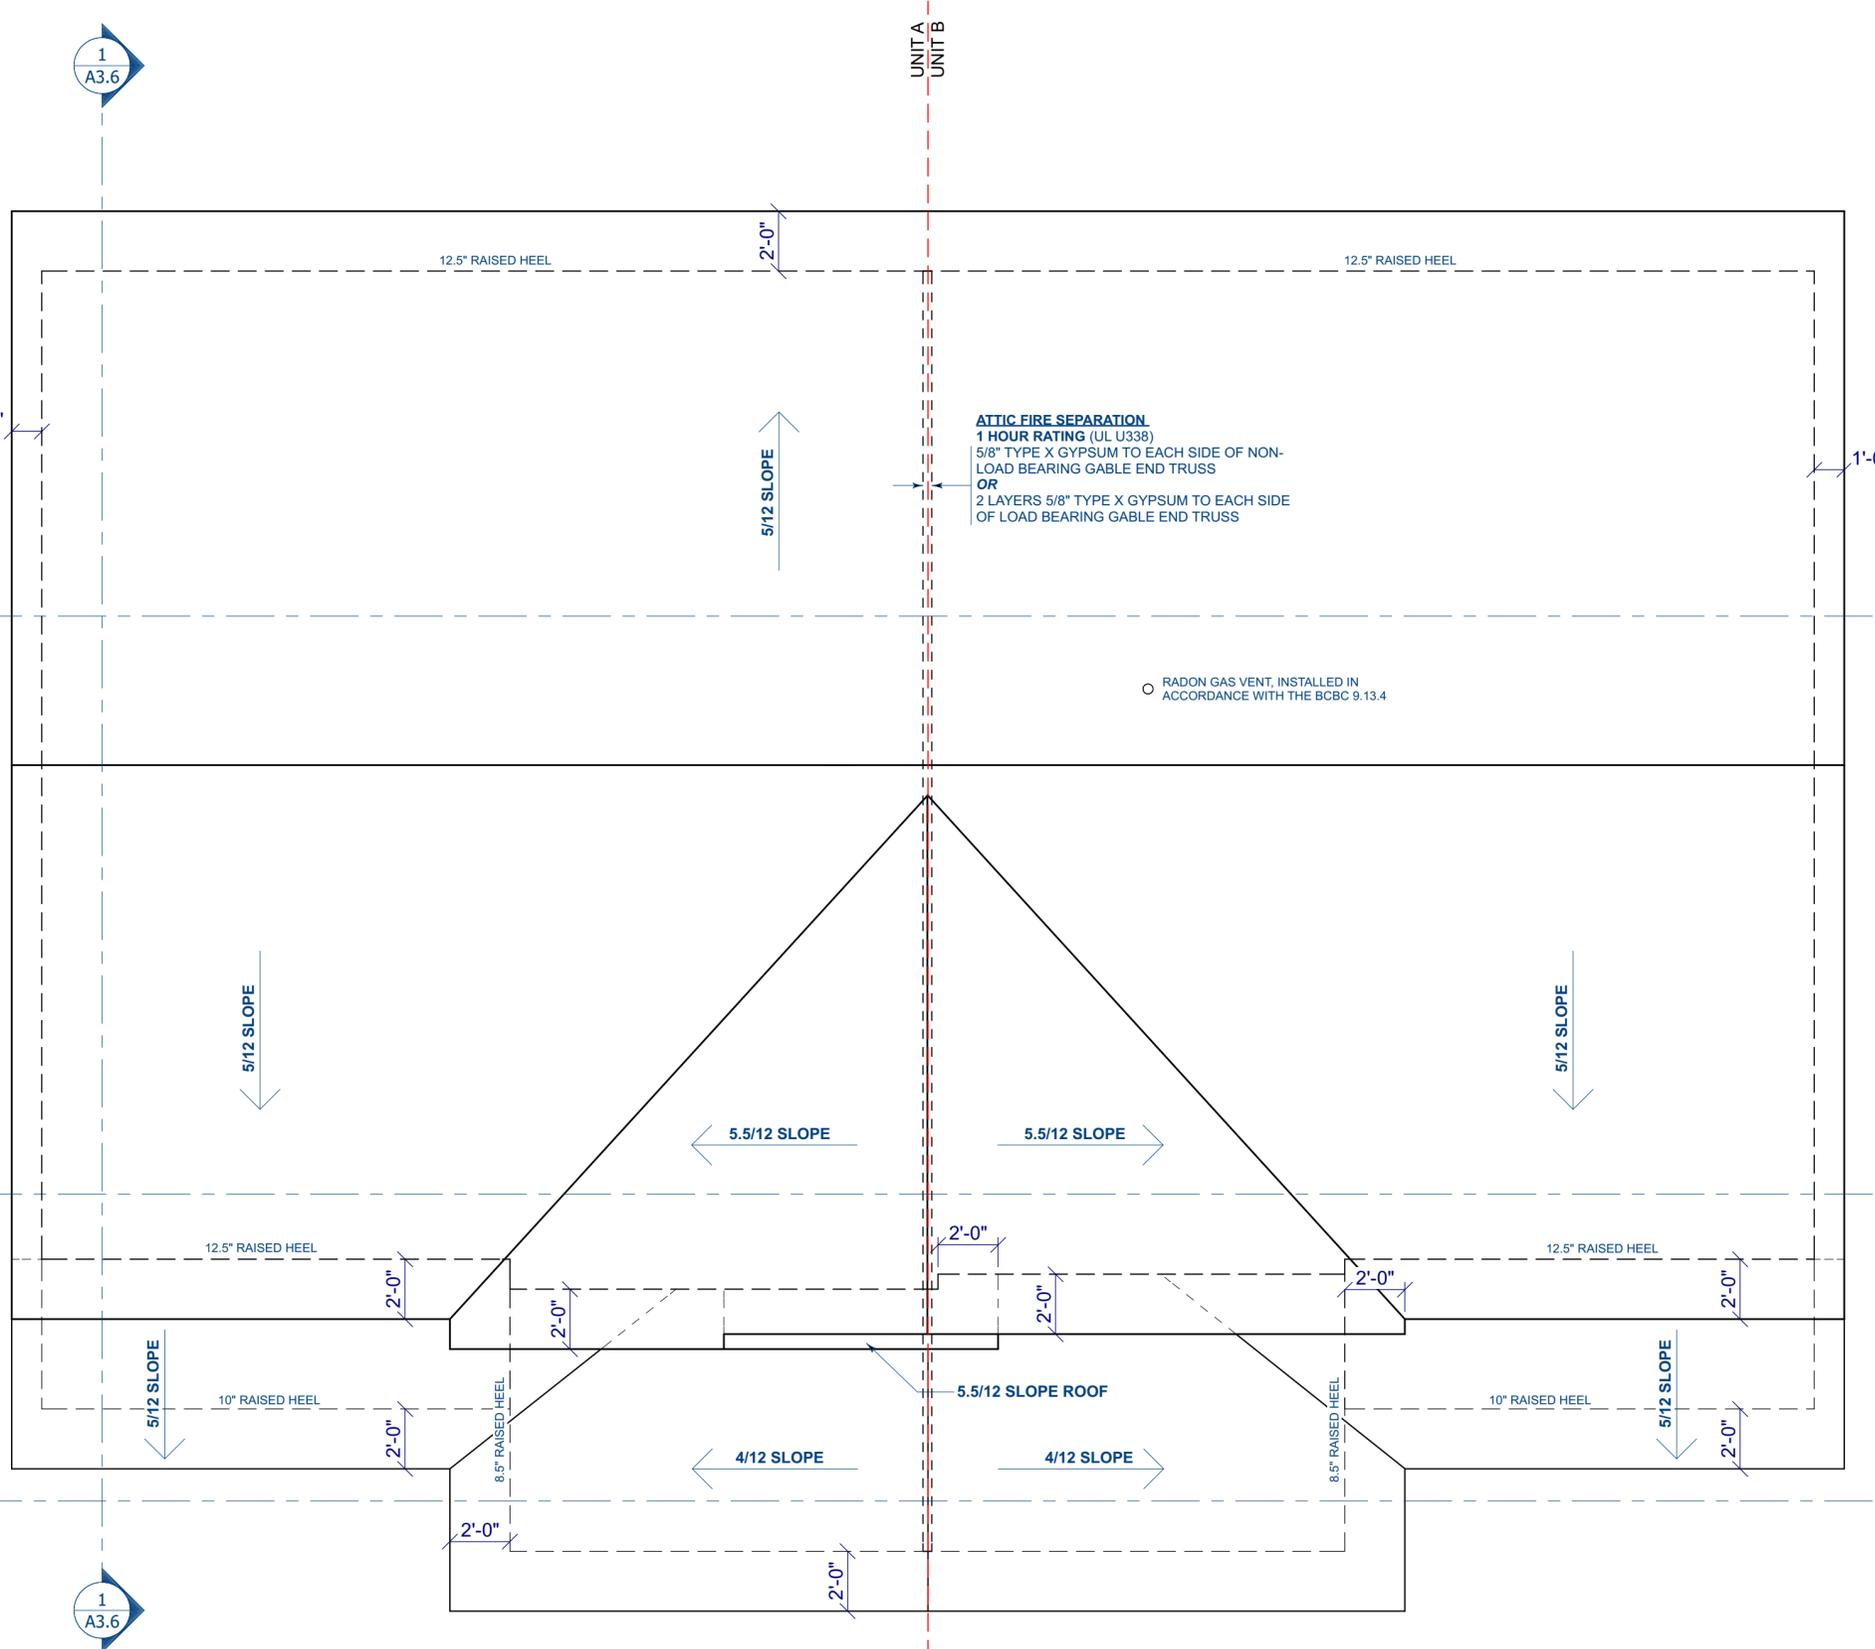

ATTIC FIRE SEPARATION
1 HOUR RATING (UL U338)
5/8" TYPE X GYPSUM TO EACH SIDE OF NON-LOAD BEARING GABLE END TRUSS
OR
2 LAYERS 5/8" TYPE X GYPSUM TO EACH SIDE OF LOAD BEARING GABLE END TRUSS

○ RADON GAS VENT, INSTALLED IN ACCORDANCE WITH THE BCBC 9.13.4

ROOF NOTES

1. STRUCTURAL ENGINEER TO PROVIDE DESIGN, LAYOUT, AND POSITION OF ALL ROOF TRUSSES
2. VENTILATION TO BE PROVIDED TO ALL ROOF SPACES AS PER THE BC BUILDING CODE LATEST EDITION
3. ALL WORK TO ROOFS TO BE IN ACCORDANCE WITH THE ROOFING CONTRACTORS ASSOCIATION OF BRITISH COLUMBIA ROOFING PRACTICES MANUAL
4. SBS ROOFING TO SLOPE MINIMUM 2% FOR DRAINAGE TO EAVESTROUGH AND/OR DRAIN

ROOF LEGEND

- ROOF LINE
- - - ROOF LINE BELOW
- - - EXTERIOR WALL | DECK BELOW
- /// VAULTED CEILING
- UNVENTED ALUMINUM SOFFIT (NOT REQUIRED)

BUILDING HEIGHT CALCULATION

PERMITTED BUILDING HEIGHT
CITY OF FERNIE 29'-6 5/16" | 9.0 m
DESIGN GUIDELINES N/A

ACTUAL BUILDING HEIGHT
29'-5 3/4" | 8.99 m
MEASURED FINISHED GRADE TO PEAK



1 ROOF PLAN

A2.4

GENERAL NOTES

- PLEASE READ CAREFULLY BEFORE BEGINNING PROJECT
1. WHILE EVERY ATTEMPT HAS BEEN MADE IN THE PREPARATION OF THIS PLAN TO AVOID MISTAKES, THE DESIGNER CANNOT GUARANTEE AGAINST HUMAN ERROR.
 2. THE DESIGNER IS UNABLE TO ACCEPT ANY LIABILITY FOR THE ACCURACY OR OVERALL INTEGRITY OF THESE DRAWINGS.
 3. DRAWINGS ARE NOT TO BE SCALED.
 4. ALL DRAWINGS, DIMENSIONS, DETAILS, AND NOTES TO BE REVIEWED AND CONFIRMED BY THE GENERAL CONTRACTOR BEFORE UNDERTAKING ANY WORK ON THE PROJECT. ANY DISCREPANCIES, ERRORS OR OMISSIONS TO BE REPORTED TO THE DESIGNER IMMEDIATELY BEFORE ORDERING MATERIALS OR COMMENCING CONSTRUCTION.
 5. DESIGNER IS NOT RESPONSIBLE FOR ERRORS AND OMISSIONS IN STRUCTURAL DESIGN. ALL STRUCTURAL SYSTEMS TO BE ENGINEERED BY OTHERS. STRUCTURAL LOCATIONS AND SIZES OF SONOTUBES, COLUMNS, FOOTINGS, AND BEAMS ARE A GUIDE ONLY; THEY MUST BE VERIFIED BY TRUSS / FLOOR MANUFACTURER BEFORE CONSTRUCTION BEGINS.
 6. ALL SITE DIMENSIONS AND MEASUREMENTS ARE TO BE GOVERNED AND APPROVED BY MUNICIPAL AUTHORITIES BEFORE STARTING CONSTRUCTION.
 7. ALL CONSTRUCTION TO COMPLY WITH CURRENT BUILDING CODE, REGULATIONS, RULES AND BYLAWS SET BY THE AUTHORITY HAVING JURISDICTION.
 8. ALL CONSTRUCTION TO COMPLY WITH INDUSTRY TRADE STANDARDS AND MANUFACTURER'S RECOMMENDATIONS WHERE THESE INSTRUCTIONS AND RECOMMENDATIONS ARE MORE STRINGENT THAN THAT CONTAINED ON THE DRAWING. ALL MATERIALS AND ENGINEERED COMPONENTS TO BE INSTALLED TO MANUFACTURER'S SPECIFICATIONS AND AS PER ENGINEERED DRAWINGS.
 9. FOUNDATION AND FOOTING DESIGN ARE TYPICAL ONLY AND ASSUME STANDARD SOIL CONDITIONS AS OUTLINED IN THE BC BUILDING CODE, LATEST EDITION. IT IS THE RESPONSIBILITY OF THE OWNER / GENERAL CONTRACTOR TO CONFIRM SITE CONDITIONS AND PROVIDE ENGINEERING IF REQUIRED.
 10. GENERAL CONTRACTOR TO CONFIRM FOUNDATION WALLS MEET THE REQUIRED BACKFILL HEIGHTS, SPECIFIED WALLS AND GRADES TO BE ADJUSTED TO SUIT SITE CONDITIONS. EXTERIOR GRADE & ALL ELEMENTS AFFECTED BY FINAL GRADE ARE TO BE CONFIRMED PRIOR TO CONSTRUCTION (BY OTHER).
 11. ALL WOOD FRAMING TO BE SFF #2 OR BETTER. ANY LUMBER IN CONTACT WITH CONCRETE MUST BE "PRESERVED WOOD FOUNDATION" (PW) MATERIAL.
 12. ALL LOADING & DRIFTING ARE TO BE DESIGNED BY OTHERS.
 13. PLUMBING, ELECTRICAL & HEATING BY CONTRACTOR TO CODE, LATEST EDITION.
 14. ROOF VENTS INSTALLED IN ACCORDANCE WITH THE BC BUILDING CODE 9.19.1.
 15. IN-FLOOR HEATED CONCRETE SYSTEM BY OTHERS. PROVISIONS TO BE MADE FOR SOIL GAS CONTROL AS PER BC BUILDING CODE 9.13.4.
 17. STAIRS AND HANDRAILS TO BE INSTALLED IN ACCORDANCE WITH THE BC BUILDING CODE 9.8.
 18. DOOR AND WINDOW SIZES ARE APPROXIMATE AND MAY VARY BETWEEN MANUFACTURERS. ACTUAL SIZES AND ROUGH OPENINGS TO BE OBTAINED FROM SUPPLIER. ALL DOORS & WINDOWS MUST BE MARK COMPLIANT WHERE APPLICABLE AND IN ACCORDANCE WITH BC BUILDING CODE. DOORS BETWEEN HOUSE AND GARAGE TO HAVE SELF-CLOSING MECHANISM AND WEATHER STRIPPING. FIRE RATED DOORS / w SELF CLOSURES TO BE INSTALLED IN ALL FIRE RATED WALLS.
 19. INFORMATION ON THESE DRAWINGS ASSUME THE AREA OF DOORS AND WINDOWS DO NOT EXCEED THE MAXIMUM RATIO TO WALL AREA OF 25% UNLESS NOTED OTHERWISE.
 20. WALLS GREATER THAN 12'-0" IN HEIGHT TO COMPLY WITH THE LOCAL JURISDICTION'S GLUE FOR TALL WALLS (WHERE APPLICABLE) OR BE ENGINEERED.
 21. WORKING DRAWINGS ARE A GRAPHIC REPRESENTATION ONLY - ACTUAL PRODUCTS AND MATERIALS USED MAY VARY FROM THE DEPICTION ON DRAWING.
 22. ENGINEERS DRAWINGS AND/OR STAMP AS REQUIRED SHALL BE THE RESPONSIBILITY OF THE GENERAL CONTRACTOR AND/OR THE OWNER.
 23. ANYTHING NOT COVERED IN THE PLANS WILL BE OPEN FOR NEGOTIATION BETWEEN THE OWNER AND THE GENERAL CONTRACTOR.

THE INFORMATION CONTAINED ON THIS DRAWING HAS BEEN PREPARED FOR THE SOLE PURPOSE OF THE PROJECT DESCRIBED HEREIN AND FOR THE SOLE BENEFIT OF THE OWNER. USE OF THIS INFORMATION FOR ANY PURPOSE OTHER THAN THE PROJECT DESCRIBED HEREIN IS AT THE SOLE RISK OF THE USER. ANY UNAUTHORIZED USE OF THIS INFORMATION WILL BE CONSIDERED A BREACH OF COPYRIGHT AND MAY BE PURSUED AS SUCH.



TIMBERS
home + building design

T 250 489 9022 | E kim@timbershbd.com

CLIENT

GRIFFITHS
DUPLEX

PROJECT ADDRESS
980 HAND STREET
FERNIE, BC

LEGAL ADDRESS
LOT 1/A, PLAN NEP15240,
DL 5455, KOOTENAY DISTRICT
PID: 009-503-340

DRAWING

FRONT ELEVATION

7			
6			
5			
4			
3			
2			
1			

No	REVISION	DATE	BY
1	ISSUE FOR REVIEW	11 MAR	KD

DATE: 11-MAR-24

SCALE: 1/4" = 1'-0"

A3.1

ISSUE FOR REVIEW

FLASHING
DRIP CAP FLASHING c/w END DAMS
REQUIRED OVER ALL OPENINGS AND
HORIZONTAL SIDING TRANSITIONS

UNIT A
UNIT B

4" SMART FRIEZE BOARD ADJACENT
TO BOARD & BATTEN SIDING

BOARD & BATTEN SIDING
(HARDIE | ALLURA)

ASPHALT SHINGLES

8" ALUMINUM FASCIA

VENTED ALUMINUM SOFFIT

8" SMART TRIM

4" SMART DOOR | WINDOW TRIM

VINYL WINDOWS (BLACK EXTERIOR)

6" SMART TRIM CORNER BOARD

LAP SIDING (ALLURA | HARDIE)

PT BEAM c/w CLAD IN FIR TRIM

FIR POST

BOARD & BATTEN SIDING
(HARDIE | ALLURA)

SINGLE PANEL FIBERGLASS
DOOR (STAIN FINISH)

36" ALUMINUM RAILING & SPINDLES

5/4" RADIUS PT DECKING

SMART TRIM RIM BOARD

1x6" PAINTED SLAT SCREEN

8" SMART TRIM HEADERS
ON GARAGE DOORS

STEEL-CRAFT FLUSH SERIES c/w 38x14"
LITES WITH BLACK PROVINCIAL WIDE
MUNTIN BARS (CHARCOAL COLOUR)

5/4" RADIUS PT STAIRS WITH
PAINTED SMART TRIM RISERS

29'-5 3/4"
8.98 m
BUILDING HEIGHT

1'-02" ft

5'-07" ft

EGRESS

EGRESS

EGRESS

EGRESS


EGRESS

1'-29" ft

1 FRONT ELEVATION

FLASHING
DRIP CAP FLASHING c/w END DAMS
REQUIRED OVER ALL OPENINGS AND
HORIZONTAL SIDING TRANSITIONS

UNIT B
UNIT A

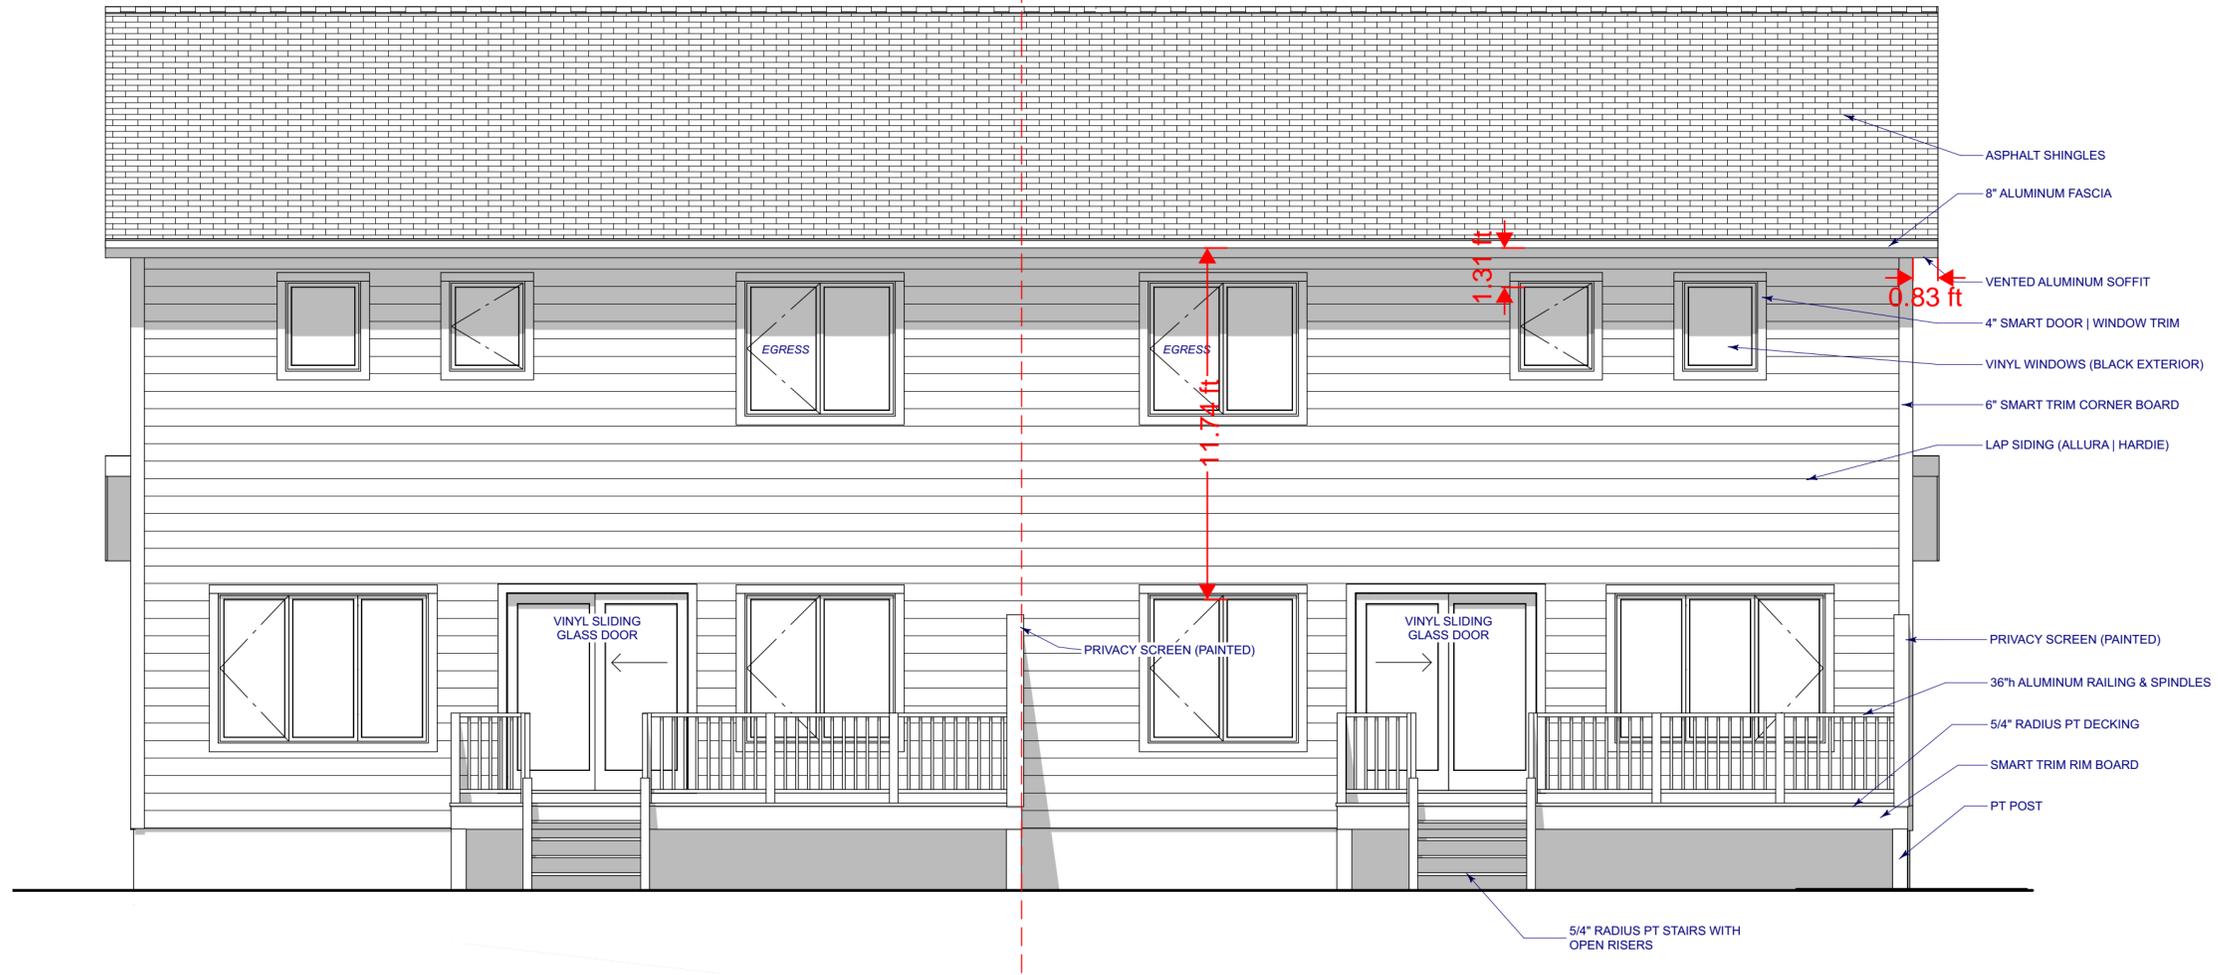

2 REAR ELEVATION

GENERAL NOTES

- PLEASE READ CAREFULLY BEFORE BEGINNING PROJECT
1. WHILE EVERY ATTEMPT HAS BEEN MADE IN THE PREPARATION OF THIS PLAN TO AVOID MISTAKES, THE DESIGNER CANNOT GUARANTEE AGAINST HUMAN ERROR.
 2. THE DESIGNER IS UNABLE TO ACCEPT ANY LIABILITY FOR THE ACCURACY OR OVERALL INTEGRITY OF THESE DRAWINGS.
 3. DRAWINGS ARE NOT TO BE SCALED.
 4. ALL DRAWINGS, DIMENSIONS, DETAILS, AND NOTES TO BE REVIEWED AND CONFIRMED BY THE GENERAL CONTRACTOR BEFORE UNDERTAKING ANY WORK ON THE PROJECT. ANY DISCREPANCIES, ERRORS OR OMISSIONS TO BE REPORTED TO THE DESIGNER IMMEDIATELY BEFORE ORDERING MATERIALS OR COMMENCING CONSTRUCTION.
 5. DESIGNER IS NOT RESPONSIBLE FOR ERRORS AND OMISSIONS IN STRUCTURAL DESIGN. ALL STRUCTURAL SYSTEMS TO BE ENGINEERED BY OTHERS. STRUCTURAL LOCATIONS AND SIZES OF SONOTUBES, COLUMNS, FOOTINGS, AND BEAMS ARE A GUIDE ONLY; THEY MUST BE VERIFIED BY TRUSS / FLOOR MANUFACTURER BEFORE CONSTRUCTION BEGINS.
 6. ALL SITE DIMENSIONS AND MEASUREMENTS ARE TO BE GOVERNED AND APPROVED BY MUNICIPAL AUTHORITIES BEFORE STARTING CONSTRUCTION.
 7. ALL CONSTRUCTION TO COMPLY WITH CURRENT BUILDING CODE, REGULATIONS, RULES AND BYLAWS SET BY THE AUTHORITY HAVING JURISDICTION.
 8. ALL CONSTRUCTION TO COMPLY WITH INDUSTRY TRADE STANDARDS AND MANUFACTURER'S RECOMMENDATIONS WHERE THESE INSTRUCTIONS AND RECOMMENDATIONS ARE MORE STRINGENT THAN THAT CONTAINED ON THE DRAWING. ALL MATERIALS AND ENGINEERED COMPONENTS TO BE INSTALLED TO MANUFACTURER'S SPECIFICATIONS AND AS PER ENGINEERED DRAWINGS.
 9. FOUNDATION AND FOOTING DESIGN ARE TYPICAL. ONLY AND ASSUME STANDARD SOIL CONDITIONS AS OUTLINED IN THE BC BUILDING CODE, LATEST EDITION. IT IS THE RESPONSIBILITY OF THE OWNER / GENERAL CONTRACTOR TO CONFIRM SITE CONDITIONS AND PROVIDE ENGINEERING IF REQUIRED.
 10. GENERAL CONTRACTOR TO CONFIRM FOUNDATION WALLS MEET THE REQUIRED BACKFILL HEIGHTS, SPECIFIED WALLS AND GRADES TO BE ADJUSTED TO SUIT SITE CONDITIONS. EXTERIOR GRADE & ALL ELEMENTS AFFECTED BY FINAL GRADE ARE TO BE CONFIRMED PRIOR TO CONSTRUCTION (BY OTHER).
 11. ALL WOOD FRAMING TO BE SPF #2 OR BETTER. ANY LUMBER IN CONTACT WITH CONCRETE MUST BE "PRESERVED WOOD FOUNDATION" (PW) MATERIAL.
 12. ALL LOADING & DRIFTING ARE TO BE DESIGNED BY OTHERS.
 13. PLUMBING, ELECTRICAL & HEATING BY CONTRACTOR TO CODE, LATEST EDITION.
 14. ROOF VENTS INSTALLED IN ACCORDANCE WITH THE BC BUILDING CODE 9.19.1.
 15. IN-FLOOR HEATED CONCRETE SYSTEM BY OTHERS. PROVISIONS TO BE MADE FOR SOIL GAS CONTROL AS PER BC BUILDING CODE 9.13.4.
 17. STAIRS AND HANDRAILS INSTALLED IN ACCORDANCE WITH THE BC BUILDING CODE 9.8.
 18. DOOR AND WINDOW SIZES ARE APPROXIMATE AND MAY VARY BETWEEN MANUFACTURERS. ACTUAL SIZES AND ROUGH OPENINGS TO BE OBTAINED FROM SUPPLIER. ALL DOORS & WINDOWS MUST BE MARK COMPLIANT WHERE APPLICABLE AND IN ACCORDANCE WITH BC BUILDING CODE. DOORS BETWEEN HOUSE AND GARAGE TO HAVE SELF-CLOSING MECHANISM AND WEATHER STRIPPING. FIRE RATED DOORS / w SELF CLOSURES TO BE INSTALLED IN ALL FIRE RATED WALLS.
 19. INFORMATION ON THESE DRAWINGS ASSUME THE AREA OF DOORS AND WINDOWS DO NOT EXCEED THE MAXIMUM RATIO TO WALL AREA OF 25% UNLESS NOTED OTHERWISE.
 20. WALLS GREATER THAN 12'-0" IN HEIGHT TO COMPLY WITH THE LOCAL JURISDICTION'S GUIDE FOR TALL WALLS (WHERE APPLICABLE) OR BE ENGINEERED.
 21. WORKING DRAWINGS ARE A GRAPHIC REPRESENTATION ONLY - ACTUAL PRODUCTS AND MATERIALS USED MAY VARY FROM THE DEPICTION ON DRAWING.
 22. ENGINEERS DRAWINGS AND/OR STAMP AS REQUIRED SHALL BE THE RESPONSIBILITY OF THE GENERAL CONTRACTOR AND/OR THE OWNER.
 23. ANYTHING NOT COVERED IN THE PLANS WILL BE OPEN FOR NEGOTIATION BETWEEN THE OWNER AND THE GENERAL CONTRACTOR.

THE INFORMATION CONTAINED ON THIS DRAWING HAS BEEN PREPARED FOR THE SOLE PURPOSE OF THE PROJECT DESCRIBED HEREIN AND FOR THE SOLE BENEFIT OF THE OWNER. USE OF THIS INFORMATION FOR ANY PURPOSE OTHER THAN THE PROJECT DESCRIBED HEREIN IS AT THE SOLE RISK OF THE USER. ANY UNAUTHORIZED USE OF THIS INFORMATION WILL BE CONSIDERED A BREACH OF COPYRIGHT AND MAY BE PUNISHED AS SUCH.



TIMBERS
home + building design

T 250 489 9022 | E kim@timbershbd.com

CLIENT

GRIFFITHS
DUPLEX

PROJECT ADDRESS
980 HAND STREET
FERNIE, BC

LEGAL ADDRESS
LOT 1/A, PLAN NEP15240,
DL 5455, KOOTENAY DISTRICT
PID: 009-503-340

DRAWING
REAR ELEVATION

7			
6			
5			
4			
3			
2			
1	ISSUE FOR REVIEW	11 MAR	KD
No	REVISION	DATE	BY

DATE
11-MAR-24

SCALE
1/4" = 1'-0"


A3.2

ISSUE FOR REVIEW

GENERAL NOTES

- PLEASE READ CAREFULLY BEFORE BEGINNING PROJECT
1. WHILE EVERY ATTEMPT HAS BEEN MADE IN THE PREPARATION OF THIS PLAN TO AVOID MISTAKES, THE DESIGNER CANNOT GUARANTEE AGAINST HUMAN ERROR.
 2. THE DESIGNER IS UNABLE TO ACCEPT ANY LIABILITY FOR THE ACCURACY OR OVERALL INTEGRITY OF THESE DRAWINGS.
 3. DRAWINGS ARE NOT TO BE SCALED.
 4. ALL DRAWINGS, DIMENSIONS, DETAILS, AND NOTES TO BE REVIEWED AND CONFIRMED BY THE GENERAL CONTRACTOR BEFORE UNDERTAKING ANY WORK ON THE PROJECT. ANY DISCREPANCIES, ERRORS OR OMISSIONS TO BE REPORTED TO THE DESIGNER IMMEDIATELY BEFORE ORDERING MATERIALS OR COMMENCING CONSTRUCTION.
 5. DESIGNER IS NOT RESPONSIBLE FOR ERRORS AND OMISSIONS IN STRUCTURAL DESIGN. ALL STRUCTURAL SYSTEMS TO BE ENGINEERED BY OTHERS. STRUCTURAL LOCATIONS AND SIZES OF SONOTUBES, COLUMNS, FOOTINGS, AND BEAMS ARE A GUIDE ONLY; THEY MUST BE VERIFIED BY TRUSS / FLOOR MANUFACTURER BEFORE CONSTRUCTION BEGINS.
 6. ALL SITE DIMENSIONS AND MEASUREMENTS ARE TO BE GOVERNED AND APPROVED BY MUNICIPAL AUTHORITIES BEFORE STARTING CONSTRUCTION.
 7. ALL CONSTRUCTION TO COMPLY WITH CURRENT BUILDING CODE, REGULATIONS, RULES AND BYLAWS SET BY THE AUTHORITY HAVING JURISDICTION.
 8. ALL CONSTRUCTION TO COMPLY WITH INDUSTRY TRADE STANDARDS AND MANUFACTURER'S RECOMMENDATIONS WHERE THESE INSTRUCTIONS AND RECOMMENDATIONS ARE MORE STRINGENT THAN THAT CONTAINED ON THE DRAWING. ALL MATERIALS AND ENGINEERED COMPONENTS TO BE INSTALLED TO MANUFACTURER'S SPECIFICATIONS AND AS PER ENGINEERED DRAWINGS.
 9. FOUNDATION AND FOOTING DESIGN ARE TYPICAL, ONLY AND ASSUME STANDARD SOIL CONDITIONS AS OUTLINED IN THE BC BUILDING CODE, LATEST EDITION. IT IS THE RESPONSIBILITY OF THE OWNER / GENERAL CONTRACTOR TO CONFIRM SITE CONDITIONS AND PROVIDE ENGINEERING IF REQUIRED.
 10. GENERAL CONTRACTOR TO CONFIRM FOUNDATION WALLS MEET THE REQUIRED BACKFILL HEIGHTS, SPECIFIED WALLS AND GRADES TO BE ADJUSTED TO SUIT SITE CONDITIONS. EXTERIOR GRADE & ALL ELEMENTS AFFECTED BY FINAL GRADE ARE TO BE CONFIRMED PRIOR TO CONSTRUCTION (BY OTHERS).
 11. ALL WOOD FRAMING TO BE SFF #2 OR BETTER. ANY LUMBER IN CONTACT WITH CONCRETE MUST BE "PRESERVED WOOD FOUNDATION" (PW) MATERIAL.
 12. ALL LOADING & DRIFTING ARE TO BE DESIGNED BY OTHERS.
 13. PLUMBING, ELECTRICAL & HEATING BY CONTRACTOR TO CODE, LATEST EDITION.
 14. ROOF VENTS INSTALLED IN ACCORDANCE WITH THE BC BUILDING CODE 9.19.1.
 15. IN-FLOOR HEATED CONCRETE SYSTEM BY OTHERS. PROVISIONS TO BE MADE FOR SOIL GAS CONTROL AS PER BC BUILDING CODE 9.13.4.
 17. STAIRS AND HANDRAILS INSTALLED IN ACCORDANCE WITH THE BC BUILDING CODE 9.8.
 18. DOOR AND WINDOW SIZES ARE APPROXIMATE AND MAY VARY BETWEEN MANUFACTURERS. ACTUAL SIZES AND ROUGH OPENINGS TO BE OBTAINED FROM SUPPLIER. ALL DOORS & WINDOWS MUST BE MARK COMPLIANT WHERE APPLICABLE AND IN ACCORDANCE WITH BC BUILDING CODE. DOORS BETWEEN HOUSE AND GARAGE TO HAVE SELF-CLOSING MECHANISM AND WEATHER STRIPPING. FIRE RATED DOORS w/ w SELF CLOSURES TO BE INSTALLED IN ALL FIRE RATED WALLS.
 19. INFORMATION ON THESE DRAWINGS ASSUME THE AREA OF DOORS AND WINDOWS DO NOT EXCEED THE MAXIMUM RATIO TO WALL AREA OF 25% UNLESS NOTED OTHERWISE.
 20. WALLS GREATER THAN 12'-0" IN HEIGHT TO COMPLY WITH THE LOCAL JURISDICTION'S GLUE FOR TALL WALLS (WHERE APPLICABLE) OR BE ENGINEERED.
 21. WORKING DRAWINGS ARE A GRAPHIC REPRESENTATION ONLY - ACTUAL PRODUCTS AND MATERIALS USED MAY VARY FROM THE DEPICTION ON DRAWING.
 22. ENGINEERS DRAWINGS AND/OR STAMP AS REQUIRED SHALL BE THE RESPONSIBILITY OF THE GENERAL CONTRACTOR AND/OR THE OWNER.
 23. ANYTHING NOT COVERED IN THE PLANS WILL BE OPEN FOR NEGOTIATION BETWEEN THE OWNER AND THE GENERAL CONTRACTOR.

FLASHING
DRIP CAP FLASHING c/w END DAMS
REQUIRED OVER ALL OPENINGS AND
HORIZONTAL SIDING TRANSITIONS

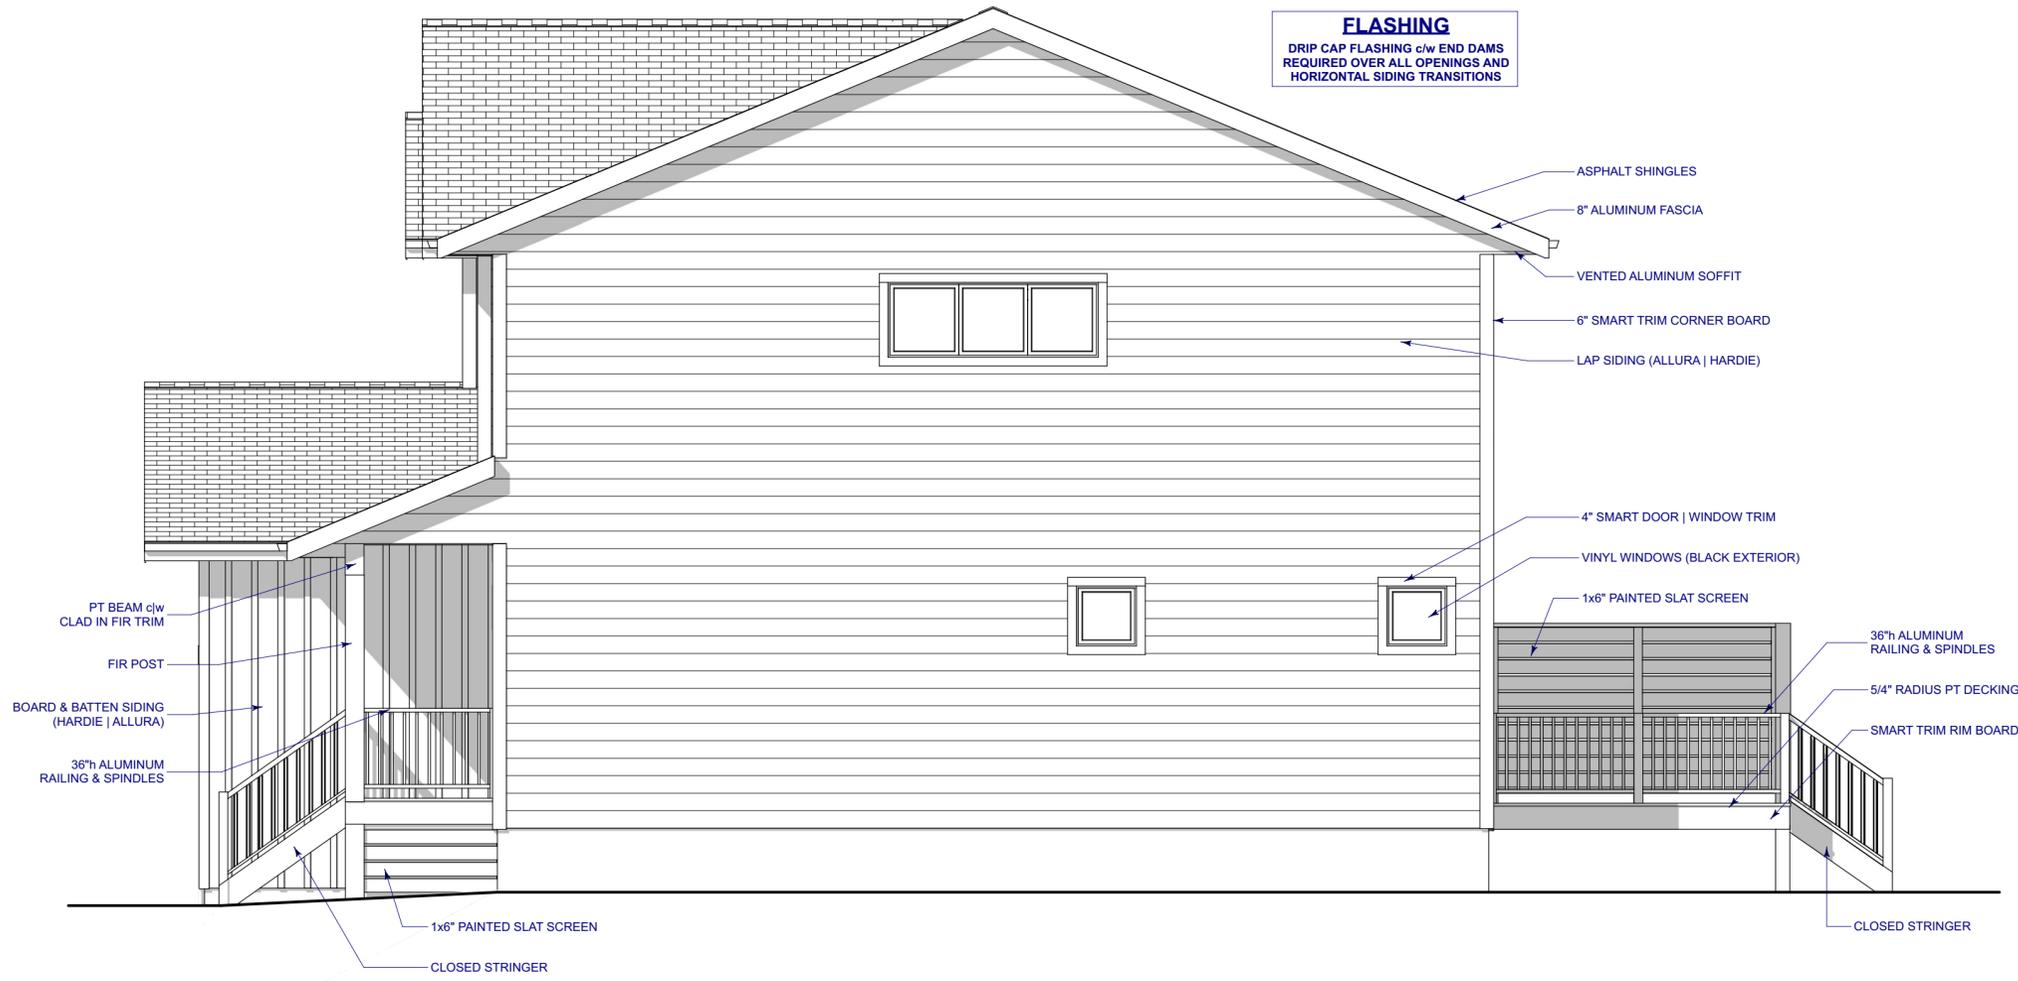


1 RIGHT-SIDE ELEVATION

GLAZED OPENING CALCULATION

LIMITING DISTANCE	1.58 m 5'-2 3/16"
WALL AREA	65.9 m ² 709.5 sq ft
ALLOWABLE GLAZED AREA	8 % 56.8 sq ft
ACTUAL GLAZED AREA	
LOFT	17.5 sq ft
LIVING	8.0 sq ft
TOTAL	25.5 sq ft

NOTE: ROOF OVERHANGS ARE NOT WITHIN 1.2m (3'-11 1/4") OF PROPERTY LINE, SO VENTED ALUMINUM SOFFIT IS PERMITTED

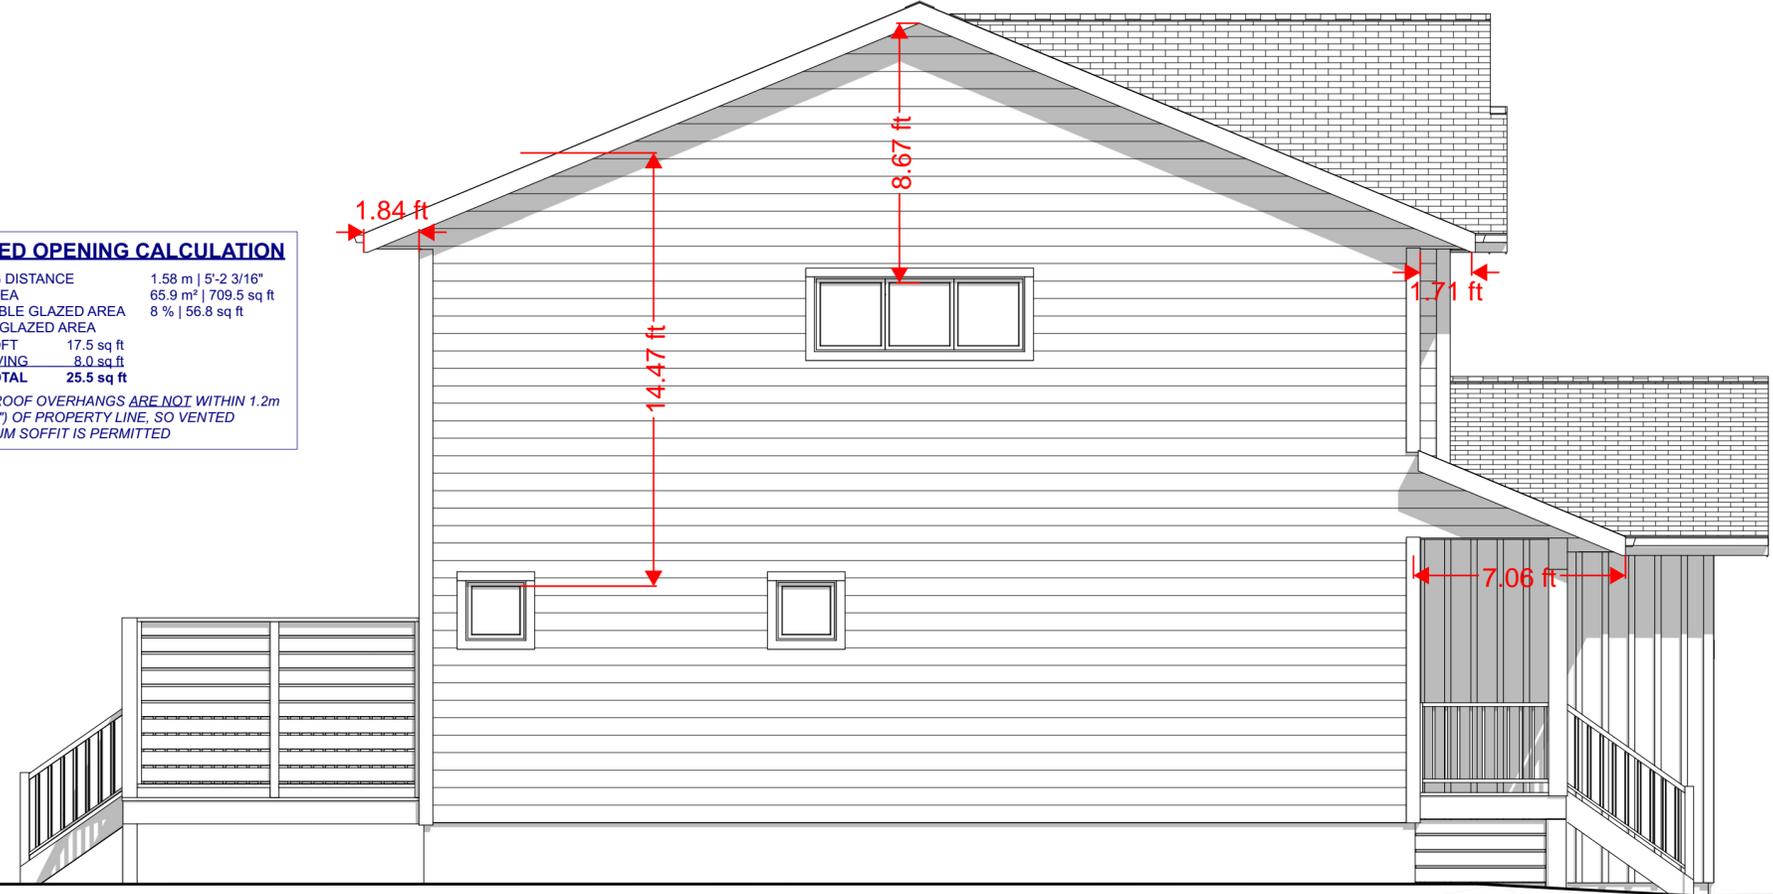

2 LEFT-SIDE ELEVATION

ISSUE FOR REVIEW

THE INFORMATION CONTAINED ON THIS DRAWING HAS BEEN PREPARED FOR THE SOLE PURPOSE OF THE PROJECT DESCRIBED HEREIN AND FOR THE SOLE BENEFIT OF THE OWNER. USE OF THIS INFORMATION FOR ANY PURPOSE OTHER THAN THE PROJECT DESCRIBED HEREIN IS AT THE SOLE RISK OF THE USER. ANY UNAUTHORIZED USE OF THIS INFORMATION WILL BE CONSIDERED A BREACH OF COPYRIGHT AND MAY BE PURSUED AS SUCH.

TIMBERS
home + building design
T 250 489 9022 | E kim@timbershbd.com

GRIFFITHS
DUPLEX

PROJECT ADDRESS
980 HAND STREET
FERNIE, BC

LEGAL ADDRESS
LOT 1/A, PLAN NEP15240,
DL 5455, KOOTENAY DISTRICT
PID: 009-503-340

SIDE ELEVATIONS

7			
6			
5			
4			
3			
2			
1	ISSUE FOR REVIEW	11 MAR	KD
No	REVISION	DATE	BY
DATE	PAGE No.		
11-MAR-24	A3.3		
SCALE	1/4" = 1'-0"		

GENERAL NOTES

- PLEASE READ CAREFULLY BEFORE BEGINNING PROJECT
1. WHILE EVERY ATTEMPT HAS BEEN MADE IN THE PREPARATION OF THIS PLAN TO AVOID MISTAKES, THE DESIGNER CANNOT GUARANTEE AGAINST HUMAN ERROR.
 2. THE DESIGNER IS UNABLE TO ACCEPT ANY LIABILITY FOR THE ACCURACY OR OVERALL INTEGRITY OF THESE DRAWINGS.
 3. DRAWINGS ARE NOT TO BE SCALED.
 4. ALL DIMENSIONS, DETAILS, AND NOTES TO BE REVIEWED AND CONFIRMED BY THE GENERAL CONTRACTOR BEFORE UNDERTAKING ANY WORK ON THE PROJECT. ANY DISCREPANCIES, ERRORS OR OMISSIONS TO BE REPORTED TO THE DESIGNER IMMEDIATELY BEFORE ORDERING MATERIALS OR COMMENCING CONSTRUCTION.
 5. DESIGNER IS NOT RESPONSIBLE FOR ERRORS AND OMISSIONS IN STRUCTURAL DESIGN. ALL STRUCTURAL SYSTEMS TO BE ENGINEERED BY OTHERS. STRUCTURAL LOCATIONS AND SIZES OF SONOTUBES, COLUMNS, FOOTINGS, AND BEAMS ARE A GUIDE ONLY; THEY MUST BE VERIFIED BY TRUSS/FLOOR MANUFACTURER BEFORE CONSTRUCTION BEGINS.
 6. ALL SITE DIMENSIONS AND MEASUREMENTS ARE TO BE GOVERNED AND APPROVED BY MUNICIPAL AUTHORITIES BEFORE STARTING CONSTRUCTION.
 7. ALL CONSTRUCTION TO COMPLY WITH CURRENT BUILDING CODE, REGULATIONS, RULES AND BYLAWS SET BY THE AUTHORITY HAVING JURISDICTION.
 8. ALL CONSTRUCTION TO COMPLY WITH INDUSTRY TRADE STANDARDS AND MANUFACTURER'S RECOMMENDATIONS WHERE THESE INSTRUCTIONS AND RECOMMENDATIONS ARE MORE STRINGENT THAN THAT CONTAINED ON THE DRAWING. ALL MATERIALS AND ENGINEERED COMPONENTS TO BE INSTALLED TO MANUFACTURER'S SPECIFICATIONS AND AS PER ENGINEER'S DRAWINGS.
 9. FOUNDATION AND FOOTING DESIGN ARE TYPICAL ONLY AND ASSUME STANDARD SOIL CONDITIONS AS OUTLINED IN THE BC BUILDING CODE, LATEST EDITION. IT IS THE RESPONSIBILITY OF THE OWNER/GENERAL CONTRACTOR TO CONFIRM SITE CONDITIONS AND PROVIDE ENGINEERING IF REQUIRED.
 10. GENERAL CONTRACTOR TO CONFIRM FOUNDATION WALLS MEET THE REQUIRED BACKFILL HEIGHTS, SPECIFIED WALLS AND GRADES TO BE ADJUSTED TO SUIT SITE CONDITIONS. EXTERIOR GRADE & ALL ELEMENTS AFFECTED BY FINAL GRADE ARE TO BE CONFIRMED PRIOR TO CONSTRUCTION (BY OTHER).
 11. ALL WOOD FRAMING TO BE SPF #2 OR BETTER. ANY LUMBER IN CONTACT WITH CONCRETE MUST BE "PRESERVED WOOD FOUNDATION (PW) MATERIAL".
 12. ALL LOADING & DRIFTING ARE TO BE DESIGNED BY OTHERS.
 13. PLUMBING, ELECTRICAL & HEATING BY CONTRACTOR TO CODE, LATEST EDITION.
 14. ROOF VENTS INSTALLED IN ACCORDANCE WITH THE BC BUILDING CODE 9.19.1.
 15. IN-FLOOR HEATED CONCRETE SYSTEM BY OTHERS. PROVISIONS TO BE MADE FOR SOIL GAS CONTROL AS PER BC BUILDING CODE 9.13.4.
 17. STAIRS AND HANDRAILS INSTALLED IN ACCORDANCE WITH THE BC BUILDING CODE 9.8.
 18. DOOR AND WINDOW SIZES ARE APPROXIMATE AND MAY VARY BETWEEN MANUFACTURERS. ACTUAL SIZES AND ROUGH OPENINGS TO BE OBTAINED FROM SUPPLIER. ALL DOORS & WINDOWS MUST BE MARK COMPLIANT WHERE APPLICABLE AND IN ACCORDANCE WITH BC BUILDING CODE. DOORS BETWEEN HOUSE AND GARAGE TO HAVE SELF-CLOSING MECHANISM AND WEATHER STRIPPING. FIRE RATED DOORS w/ w SELF CLOSURES TO BE INSTALLED IN ALL FIRE RATED WALLS.
 19. INFORMATION ON THESE DRAWINGS ASSUME THE AREA OF DOORS AND WINDOWS DO NOT EXCEED THE MAXIMUM RATIO TO WALL AREA OF 25% UNLESS NOTED OTHERWISE.
 20. WALLS GREATER THAN 12'-0" IN HEIGHT TO COMPLY WITH THE LOCAL JURISDICTION'S GLUE FOR TALL WALLS (WHERE APPLICABLE) OR BE ENGINEERED.
 21. WORKING DRAWINGS ARE A GRAPHIC REPRESENTATION ONLY - ACTUAL PRODUCTS AND MATERIALS USED MAY VARY FROM THE DIRECTION ON DRAWING.
 22. ENGINEERS DRAWINGS AND/OR STAMP AS REQUIRED SHALL BE THE RESPONSIBILITY OF THE GENERAL CONTRACTOR AND/OR THE OWNER.
 23. ANYTHING NOT COVERED IN THE PLANS WILL BE OPEN FOR NEGOTIATION BETWEEN THE OWNER AND THE GENERAL CONTRACTOR.

AIR BARRIER NOTE
AIR BARRIER TO BE STRUCTURALLY SUPPORTED AT SEAMS AND ALL PENETRATIONS, INCLUDING ELECTRICAL BOXES AND WIRE WAYS, TO BE CAULKED.

ROOF VENTILATION TO BE INSTALLED IN ACCORDANCE WITH THE BC BUILDING CODE 2024 (9.19.1)

ALL INSULATION VALUES TO BE CONFIRMED BY ENERGY ADVISOR


EXTERIOR WALL
EXTERIOR SIDING
TYPAR BUILDING WRAP
7/16" OSB
2x6" STUDS @ 16"oc
R-24 BATT INSULATION
6mm CJSB POLY
1/2" GYPSUM

2lbs SPRAY FOAM INSULATION IN JOIST ENDS. ROXUL INSULATION TO PROTECT WHERE CEILING UNFINISHED

TOP PLATE AS PER ENGINEERED FOUNDATION DRAWINGS
SLOPE GRADE MIN. 2% FOR DRAINAGE

SUPERIOR FOUNDATION WALL
ASPHALT EMULSION WITH MASTIC DAMPPROOFING INSTALLED AS PER THE BCBC 9.13
ENGINEERED SUPERIOR WALL XI PLUS FOUNDATION WALL
* VAPOUR BARRIER NOT REQUIRED AS PER THE SUPERIOR WALL SPECS (ASTM E96)
AIR BARRIER TO BE CONFIRMED

BUILDING PAPER
DRAINAGE ROCK
4" dia PERFORATED PIPING
8x24" REINF. CONCRETE STRIP FOOTING

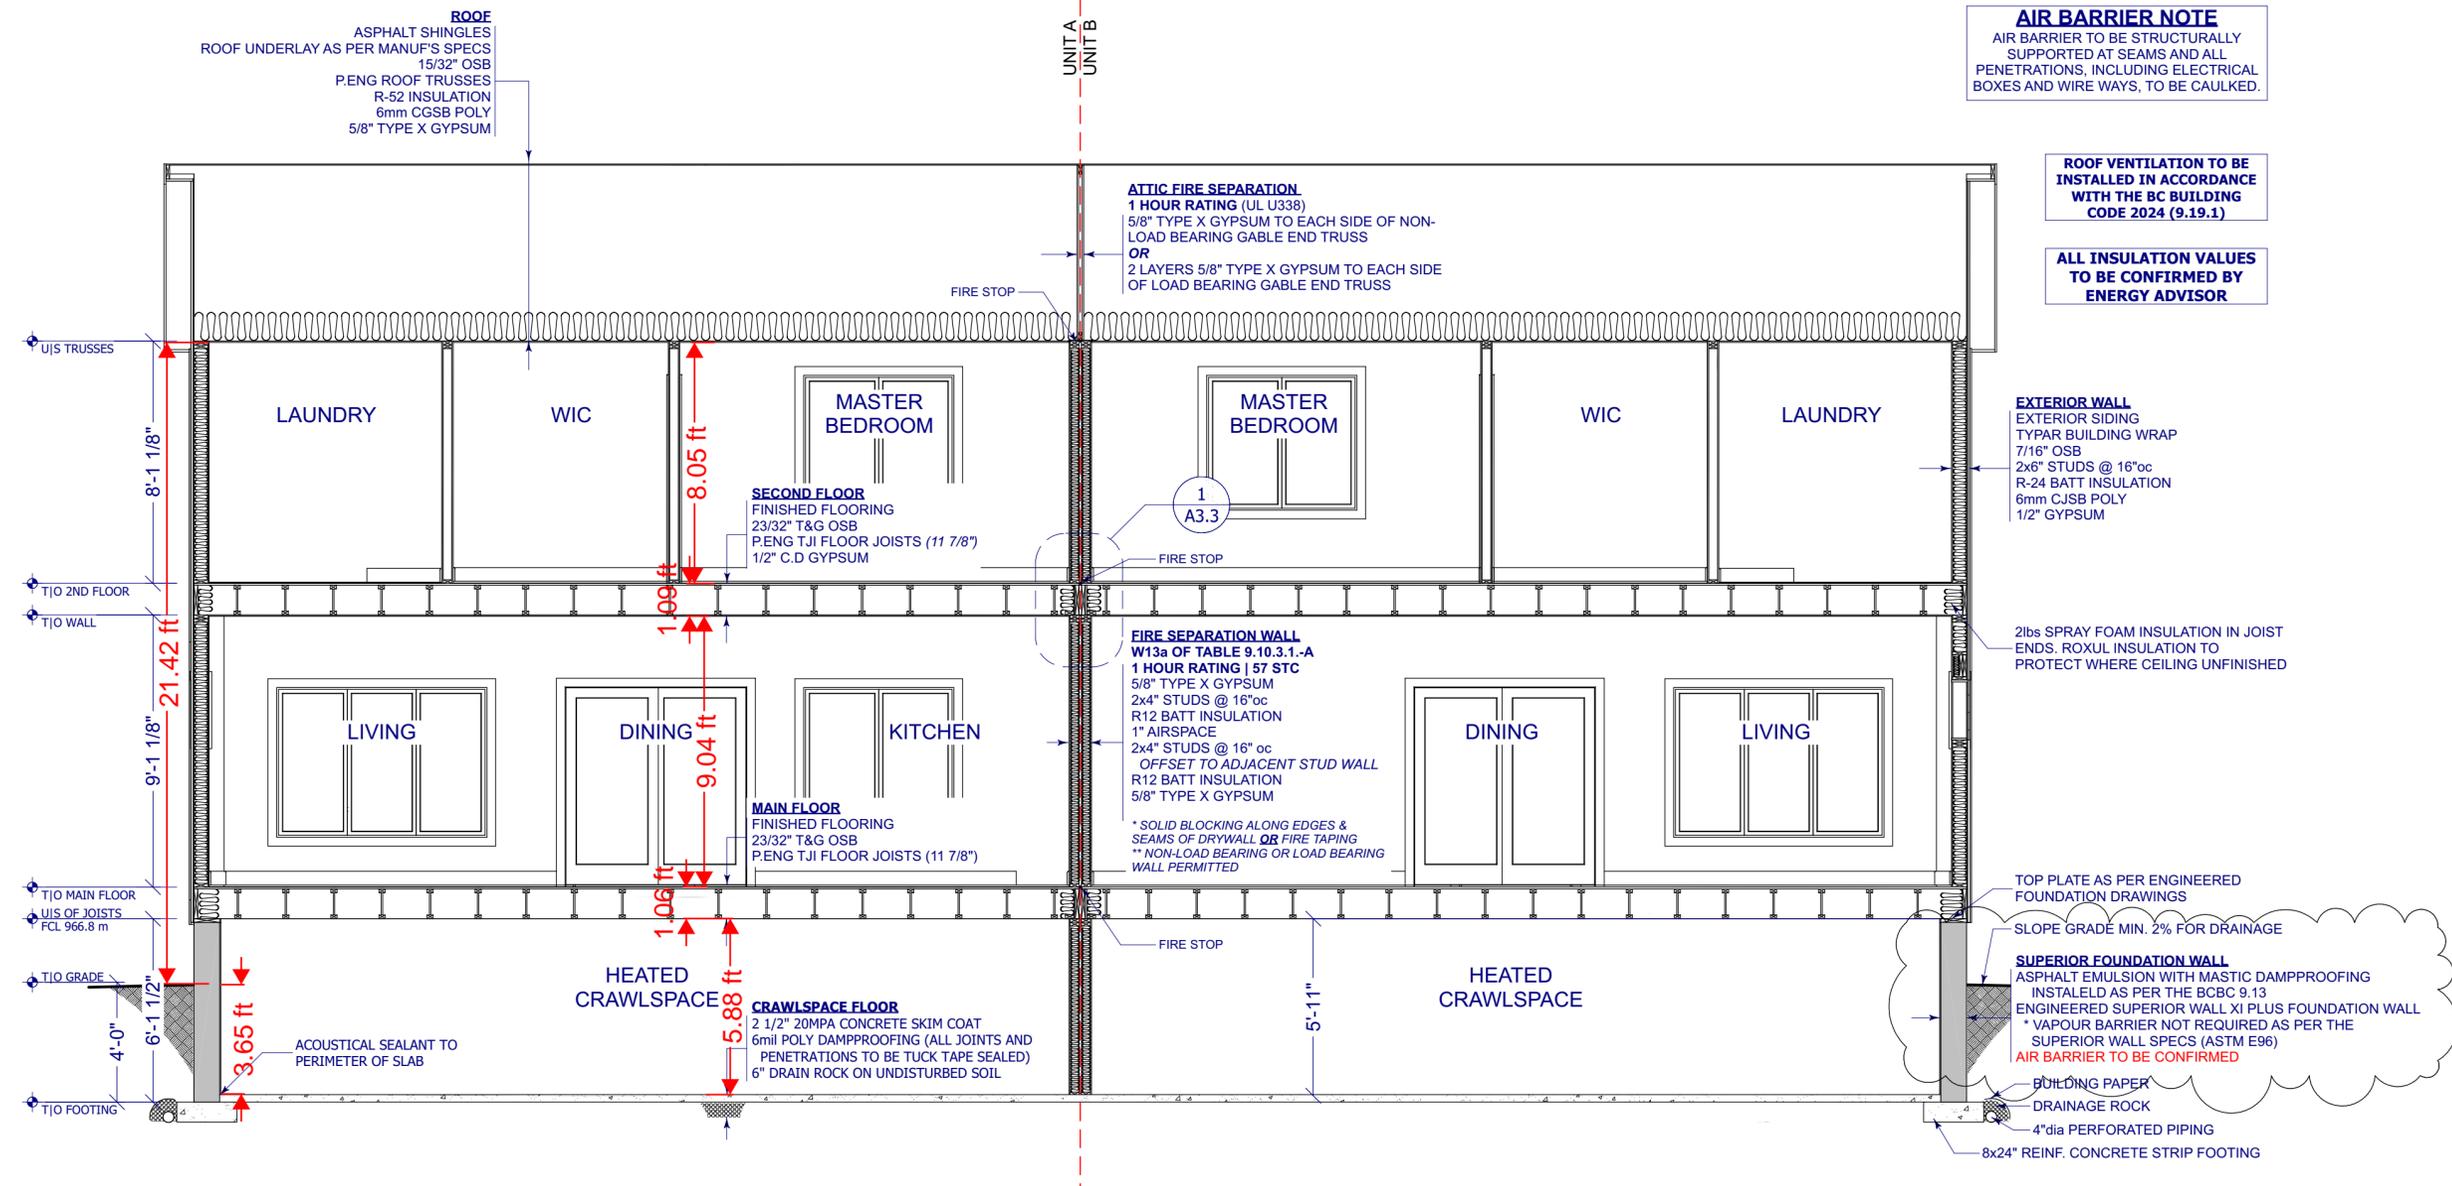

ROOF
ASPHALT SHINGLES
ROOF UNDERLAY AS PER MANUF'S SPECS
15/32" OSB
P.ENG ROOF TRUSSES
R-52 INSULATION
6mm CGSB POLY
5/8" TYPE X GYPSUM

ATTIC FIRE SEPARATION
1 HOUR RATING (UL U338)
5/8" TYPE X GYPSUM TO EACH SIDE OF NON-LOAD BEARING GABLE END TRUSS
OR
2 LAYERS 5/8" TYPE X GYPSUM TO EACH SIDE OF LOAD BEARING GABLE END TRUSS


FIRE SEPARATION WALL
W13a OF TABLE 9.10.3.1.-A
1 HOUR RATING | 57 STC
5/8" TYPE X GYPSUM
2x4" STUDS @ 16"oc
R12 BATT INSULATION
1" AIRSPACE
2x4" STUDS @ 16" oc
OFFSET TO ADJACENT STUD WALL
R12 BATT INSULATION
5/8" TYPE X GYPSUM
* SOLID BLOCKING ALONG EDGES & SEAMS OF DRYWALL OR FIRE TAPING
** NON-LOAD BEARING OR LOAD BEARING WALL PERMITTED

SECOND FLOOR
FINISHED FLOORING
23/32" T&G OSB
P.ENG TJI FLOOR JOISTS (11 7/8")
1/2" C.D GYPSUM

MAIN FLOOR
FINISHED FLOORING
23/32" T&G OSB
P.ENG TJI FLOOR JOISTS (11 7/8")

CRAWLSPACE FLOOR
2 1/2" 20MPA CONCRETE SKIM COAT
6mil POLY DAMPPROOFING (ALL JOINTS AND PENETRATIONS TO BE TUCK TAPE SEALED)
6" DRAIN ROCK ON UNDISTURBED SOIL

1 BUILDING SECTION I
3/16" = 1'-0"

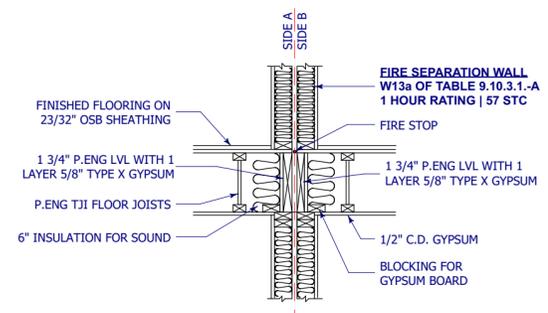

2 FLOOR DETAIL CONTINUITY OF FIRE SEPARATION
1/2" = 1'-0"

ISSUE FOR REVIEW



GRIFFITHS DUPLEX

PROJECT ADDRESS
980 HAND STREET
FERNIE, BC

LEGAL ADDRESS
LOT 1/A, PLAN NEP15240,
DL 5455, KOOTENAY DISTRICT
PID: 009-503-340

DRAWING
BUILDING SECTION I & FLOOR DETAIL


7			
6			
5			
4			
3			
2			
1	ISSUE FOR REVIEW	11 MAR	KD
No	REVISION	DATE	BY

DATE: 11-MAR-24
SCALE: AS SHOWN
A3.3

GENERAL NOTES

- PLEASE READ CAREFULLY BEFORE BEGINNING PROJECT
1. WHILE EVERY ATTEMPT HAS BEEN MADE IN THE PREPARATION OF THIS PLAN TO AVOID MISTAKES, THE DESIGNER CANNOT GUARANTEE AGAINST HUMAN ERROR.
 2. THE DESIGNER IS UNABLE TO ACCEPT ANY LIABILITY FOR THE ACCURACY OR OVERALL INTEGRITY OF THESE DRAWINGS.
 3. DRAWINGS ARE NOT TO BE SCALED.
 4. ALL DRAWINGS, DIMENSIONS, DETAILS, AND NOTES TO BE REVIEWED AND CONFIRMED BY THE GENERAL CONTRACTOR BEFORE UNDERTAKING ANY WORK ON THE PROJECT. ANY DISCREPANCIES, ERRORS OR OMISSIONS TO BE REPORTED TO THE DESIGNER IMMEDIATELY BEFORE ORDERING MATERIALS OR COMMENCING CONSTRUCTION.
 5. DESIGNER IS NOT RESPONSIBLE FOR ERRORS AND OMISSIONS IN STRUCTURAL DESIGN. ALL STRUCTURAL SYSTEMS TO BE ENGINEERED BY OTHERS. STRUCTURAL LOCATIONS AND SIZES OF SONOTUBES, COLUMNS, FOOTINGS, AND BEAMS ARE A GUIDE ONLY. THEY MUST BE VERIFIED BY TRUSS / FLOOR MANUFACTURER BEFORE CONSTRUCTION BEGINS.
 6. ALL SITE DIMENSIONS AND MEASUREMENTS ARE TO BE GOVERNED AND APPROVED BY MUNICIPAL AUTHORITIES BEFORE STARTING CONSTRUCTION.
 7. ALL CONSTRUCTION TO COMPLY WITH CURRENT BUILDING CODE, REGULATIONS, RULES AND BYLAWS SET BY THE AUTHORITY HAVING JURISDICTION.
 8. ALL CONSTRUCTION TO COMPLY WITH INDUSTRY TRADE STANDARDS AND MANUFACTURER'S RECOMMENDATIONS WHERE THESE INSTRUCTIONS AND RECOMMENDATIONS ARE MORE STRINGENT THAN THAT CONTAINED ON THE DRAWING. ALL MATERIALS AND ENGINEERED COMPONENTS TO BE INSTALLED TO MANUFACTURER'S SPECIFICATIONS AND AS PER ENGINEERED DRAWINGS.
 9. FOUNDATION AND FOOTING DESIGN ARE TYPICAL ONLY AND ASSUME STANDARD SOIL CONDITIONS AS OUTLINED IN THE BC BUILDING CODE, LATEST EDITION. IT IS THE RESPONSIBILITY OF THE OWNER / GENERAL CONTRACTOR TO CONFIRM SITE CONDITIONS AND PROVIDE ENGINEERING IF REQUIRED.
 10. GENERAL CONTRACTOR TO CONFIRM FOUNDATION WALLS MEET THE REQUIRED BACKFILL HEIGHTS, SPECIFIED WALLS AND GRADES TO BE ADJUSTED TO SUIT SITE CONDITIONS. EXTERIOR GRADE & ALL ELEMENTS AFFECTED BY FINAL GRADE ARE TO BE CONFIRMED PRIOR TO CONSTRUCTION (BY OTHER).
 11. ALL WOOD FRAMING TO BE SPF #2 OR BETTER. ANY LUMBER IN CONTACT WITH CONCRETE MUST BE "PRESERVED WOOD FOUNDATION" (PW) MATERIAL.
 12. ALL LOADING & DRIFTING ARE TO BE DESIGNED BY OTHERS.
 13. PLUMBING, ELECTRICAL & HEATING BY CONTRACTOR TO CODE, LATEST EDITION.
 14. ROOF VENTS INSTALLED IN ACCORDANCE WITH THE BC BUILDING CODE 9.19.1.
 15. IN-FLOOR HEATED CONCRETE SYSTEM BY OTHERS. PROVISIONS TO BE MADE FOR SOIL GAS CONTROL AS PER BC BUILDING CODE 9.13.4.
 17. STAIRS AND HANDRAILS INSTALLED IN ACCORDANCE WITH THE BC BUILDING CODE 9.8.
 18. DOOR AND WINDOW SIZES ARE APPROXIMATE AND MAY VARY BETWEEN MANUFACTURERS. ACTUAL SIZES AND ROUGH OPENINGS TO BE OBTAINED FROM SUPPLIER. ALL DOORS & WINDOWS MUST BE MARK COMPLIANT WHERE APPLICABLE AND IN ACCORDANCE WITH BC BUILDING CODE. DOORS BETWEEN HOUSE AND GARAGE TO HAVE SELF-CLOSING MECHANISM AND WEATHER STRIPPING. FIRE RATED DOORS / W SELF CLOSURES TO BE INSTALLED IN ALL FIRE RATED WALLS.
 19. INFORMATION ON THESE DRAWINGS ASSUME THE AREA OF DOORS AND WINDOWS DO NOT EXCEED THE MAXIMUM RATIO TO WALL AREA OF 25% UNLESS NOTED OTHERWISE.
 20. WALLS GREATER THAN 12'-0" IN HEIGHT TO COMPLY WITH THE LOCAL JURISDICTION'S GLUE FOR TALL WALLS (WHERE APPLICABLE) OR BE ENGINEERED.
 21. WORKING DRAWINGS ARE A GRAPHIC REPRESENTATION ONLY - ACTUAL PRODUCTS AND MATERIALS USED MAY VARY FROM THE DEPICTION ON DRAWING.
 22. ENGINEERS DRAWINGS AND/OR STAMP AS REQUIRED SHALL BE THE RESPONSIBILITY OF THE GENERAL CONTRACTOR AND/OR THE OWNER.
 23. ANYTHING NOT COVERED IN THE PLANS WILL BE OPEN FOR NEGOTIATION BETWEEN THE OWNER AND THE GENERAL CONTRACTOR.

Builder changed insulation specs to R48 batt

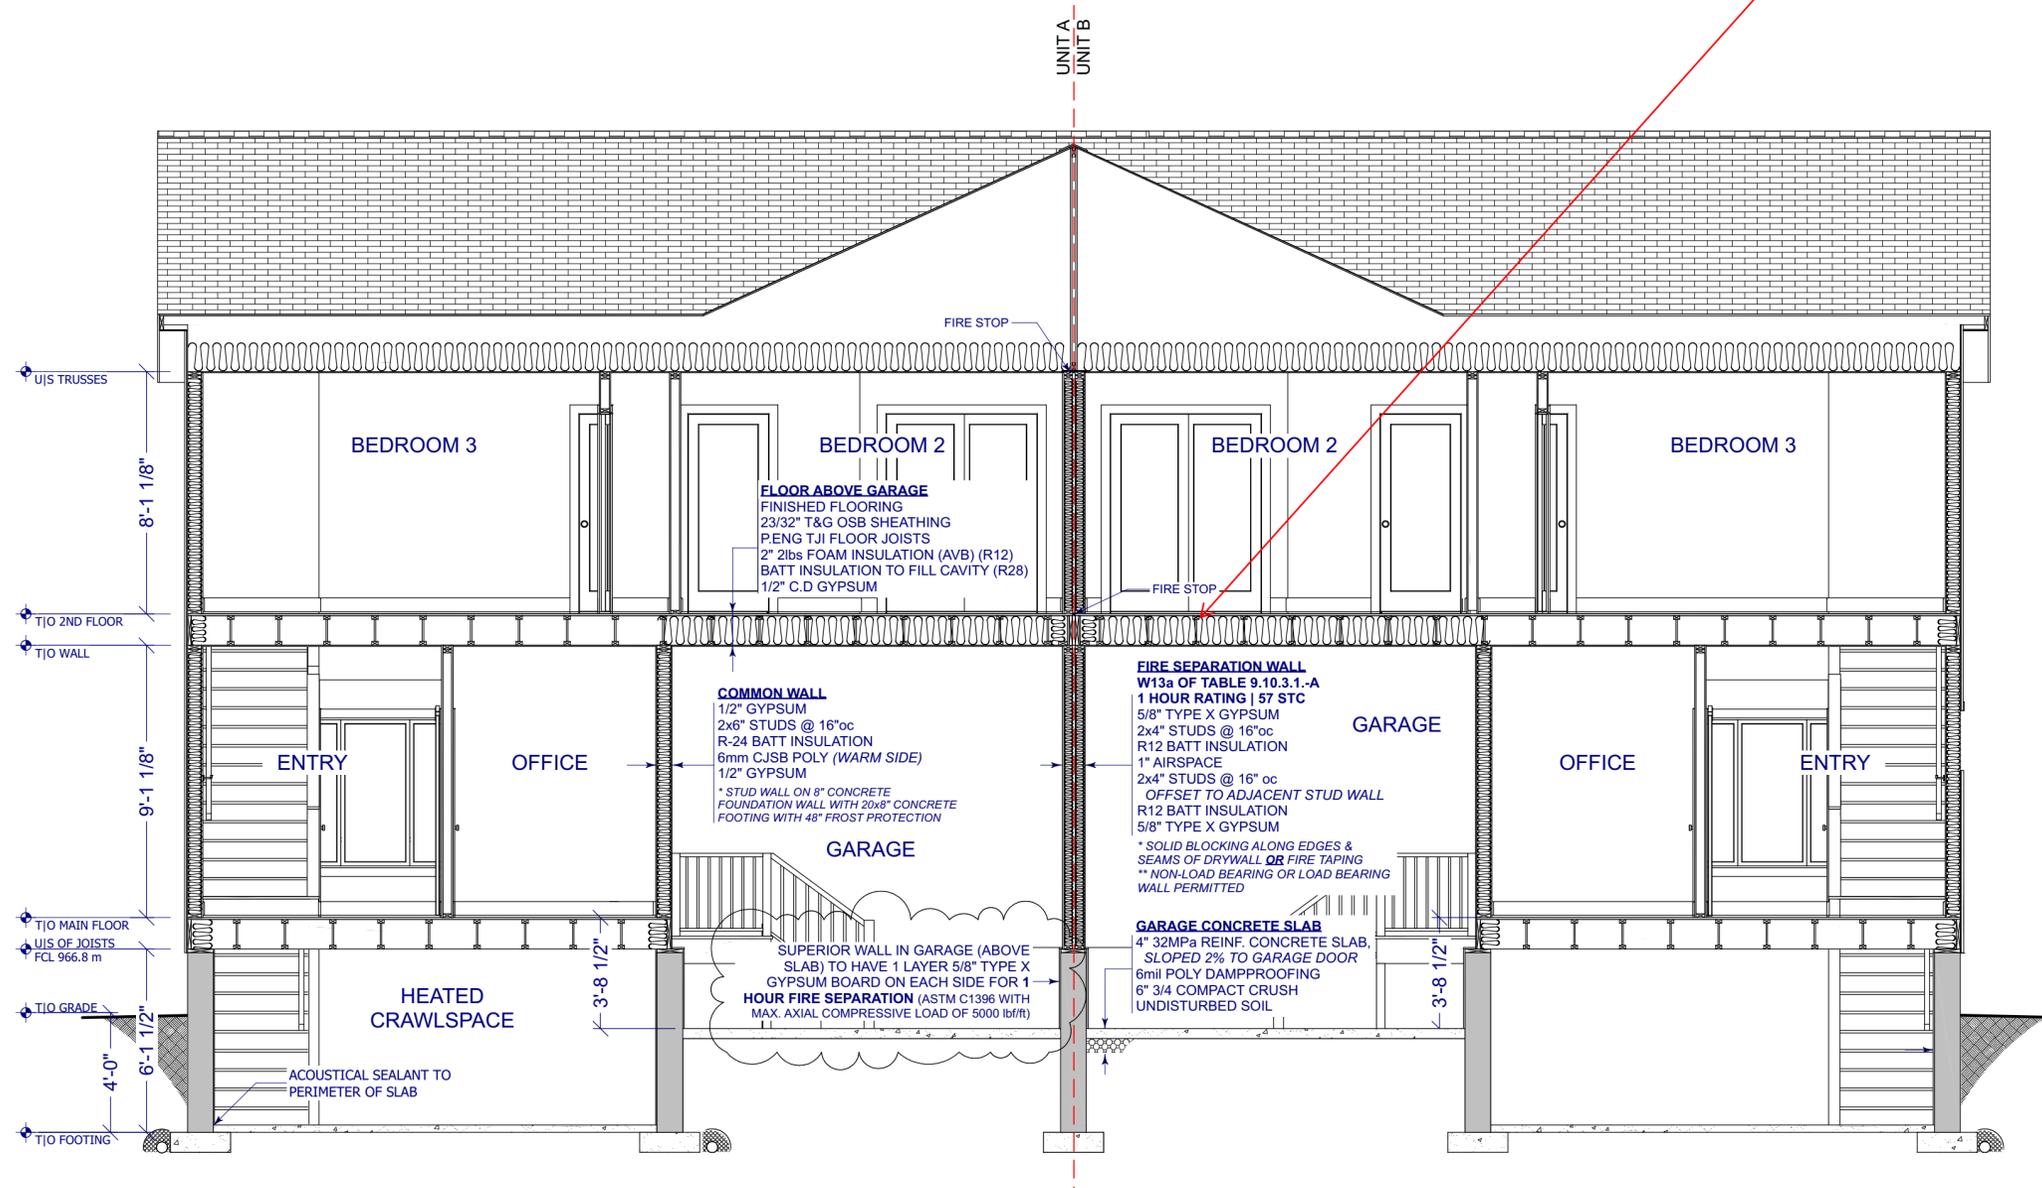

1 BUILDING SECTION II

THE INFORMATION CONTAINED ON THIS DRAWING HAS BEEN PREPARED FOR THE SOLE PURPOSE OF THE PROJECT DESCRIBED HEREIN AND FOR THE SOLE BENEFIT OF THE OWNER. USE OF THIS INFORMATION FOR ANY PURPOSE OTHER THAN THE PROJECT DESCRIBED HEREIN IS AT THE SOLE RISK OF THE USER. ANY UNAUTHORIZED USE OF THIS INFORMATION WILL BE CONSIDERED A BREACH OF COPYRIGHT AND MAY BE PURSUED AS SUCH.



TIMBERS
home + building design

T 250 489 9022 | E kim@timberhbd.com

CLIENT

GRIFFITHS
DUPLEX

PROJECT ADDRESS
980 HAND STREET
FERNIE, BC

LEGAL ADDRESS
LOT 1/A, PLAN NEP15240,
DL 5455, KOOTENAY DISTRICT
PID: 009-503-340

DRAWING
BUILDING SECTION II

7			
6			
5			
4			
3			
2			
1	ISSUE FOR REVIEW	11 MAR	KD
No	REVISION	DATE	BY

DATE
11-MAR-24


SCALE
1/4" = 1'-0"

A3.4

ISSUE FOR REVIEW

GENERAL NOTES

- PLEASE READ CAREFULLY BEFORE BEGINNING PROJECT
1. WHILE EVERY ATTEMPT HAS BEEN MADE IN THE PREPARATION OF THIS PLAN TO AVOID MISTAKES, THE DESIGNER CANNOT GUARANTEE AGAINST HUMAN ERROR.
 2. THE DESIGNER IS UNABLE TO ACCEPT ANY LIABILITY FOR THE ACCURACY OR OVERALL INTEGRITY OF THESE DRAWINGS.
 3. DRAWINGS ARE NOT TO BE SCALED.
 4. ALL DRAWINGS, DIMENSIONS, DETAILS, AND NOTES TO BE REVIEWED AND CONFIRMED BY THE GENERAL CONTRACTOR BEFORE UNDERTAKING ANY WORK ON THE PROJECT. ANY DISCREPANCIES, ERRORS OR OMISSIONS TO BE REPORTED TO THE DESIGNER IMMEDIATELY BEFORE ORDERING MATERIALS OR COMMENCING CONSTRUCTION.
 5. DESIGNER IS NOT RESPONSIBLE FOR ERRORS AND OMISSIONS IN STRUCTURAL DESIGN. ALL STRUCTURAL SYSTEMS TO BE ENGINEERED BY OTHERS. STRUCTURAL LOCATIONS AND SIZES OF SONOTUBES, COLUMNS, FOOTINGS, AND BEAMS ARE A GUIDE ONLY; THEY MUST BE VERIFIED BY TRUSS / FLOOR MANUFACTURER BEFORE CONSTRUCTION BEGINS.
 6. ALL SITE DIMENSIONS AND MEASUREMENTS ARE TO BE GOVERNED AND APPROVED BY MUNICIPAL AUTHORITIES BEFORE STARTING CONSTRUCTION.
 7. ALL CONSTRUCTION TO COMPLY WITH CURRENT BUILDING CODE, REGULATIONS, RULES AND BYLAWS SET BY THE AUTHORITY HAVING JURISDICTION.
 8. ALL CONSTRUCTION TO COMPLY WITH INDUSTRY TRADE STANDARDS AND MANUFACTURER'S RECOMMENDATIONS WHERE THESE INSTRUCTIONS AND RECOMMENDATIONS ARE MORE STRINGENT THAN THAT CONTAINED ON THE DRAWING. ALL MATERIALS AND ENGINEERED COMPONENTS TO BE INSTALLED TO MANUFACTURER'S SPECIFICATIONS AND AS PER ENGINEERED DRAWINGS.
 9. FOUNDATION AND FOOTING DESIGN ARE TYPICAL ONLY AND ASSUME STANDARD SOIL CONDITIONS AS OUTLINED IN THE BC BUILDING CODE, LATEST EDITION. IT IS THE RESPONSIBILITY OF THE OWNER / GENERAL CONTRACTOR TO CONFIRM SITE CONDITIONS AND PROVIDE ENGINEERING IF REQUIRED.
 10. GENERAL CONTRACTOR TO CONFIRM FOUNDATION WALLS MEET THE REQUIRED BACKFILL HEIGHTS, SPECIFIED WALLS AND GRADES TO BE ADJUSTED TO SUIT SITE CONDITIONS. EXTERIOR GRADES & ALL ELEMENTS AFFECTED BY FINAL GRADE ARE TO BE CONFIRMED PRIOR TO CONSTRUCTION (BY OTHER).
 11. ALL WOOD FRAMING TO BE SFF #2 OR BETTER. ANY LUMBER IN CONTACT WITH CONCRETE MUST BE "PRESERVED WOOD FOUNDATION" (PW) MATERIAL.
 12. ALL LOADING & DRIFTING ARE TO BE DESIGNED BY OTHERS.
 13. PLUMBING, ELECTRICAL & HEATING BY CONTRACTOR TO CODE, LATEST EDITION.
 14. ROOF VENTS INSTALLED IN ACCORDANCE WITH THE BC BUILDING CODE 9.13.1.
 15. IN-FLOOR HEATED CONCRETE SYSTEM BY OTHERS. PROVISIONS TO BE MADE FOR SOIL GAS CONTROL AS PER BC BUILDING CODE 9.13.4.
 17. STAIRS AND HANDRAILS INSTALLED IN ACCORDANCE WITH THE BC BUILDING CODE 9.8.
 18. DOOR AND WINDOW SIZES ARE APPROXIMATE AND MAY VARY BETWEEN MANUFACTURERS. ACTUAL SIZES AND ROUGH OPENINGS TO BE OBTAINED FROM SUPPLIER. ALL DOORS & WINDOWS MUST BE MARK COMPLIANT WHERE APPLICABLE AND IN ACCORDANCE WITH BC BUILDING CODE. DOORS BETWEEN HOUSE AND GARAGE TO HAVE SELF-CLOSING MECHANISM AND WEATHER STRIPPING. FIRE RATED DOORS w/ w SELF CLOSURES TO BE INSTALLED IN ALL FIRE RATED WALLS.
 19. INFORMATION ON THESE DRAWINGS ASSUME THE AREA OF DOORS AND WINDOWS DO NOT EXCEED THE MAXIMUM RATIO TO WALL AREA OF 25% UNLESS NOTED OTHERWISE.
 20. WALLS GREATER THAN 12'-0" IN HEIGHT TO COMPLY WITH THE LOCAL JURISDICTION'S GLUE FOR TALL WALLS (WHERE APPLICABLE) OR BE ENGINEERED.
 21. WORKING DRAWINGS ARE A GRAPHIC REPRESENTATION ONLY - ACTUAL PRODUCTS AND MATERIALS USED MAY VARY FROM THE DEPICTION ON DRAWING.
 22. ENGINEERS DRAWINGS AND/OR STAMP AS REQUIRED SHALL BE THE RESPONSIBILITY OF THE GENERAL CONTRACTOR AND/OR THE OWNER.
 23. ANYTHING NOT COVERED IN THE PLANS WILL BE OPEN FOR NEGOTIATION BETWEEN THE OWNER AND THE GENERAL CONTRACTOR.

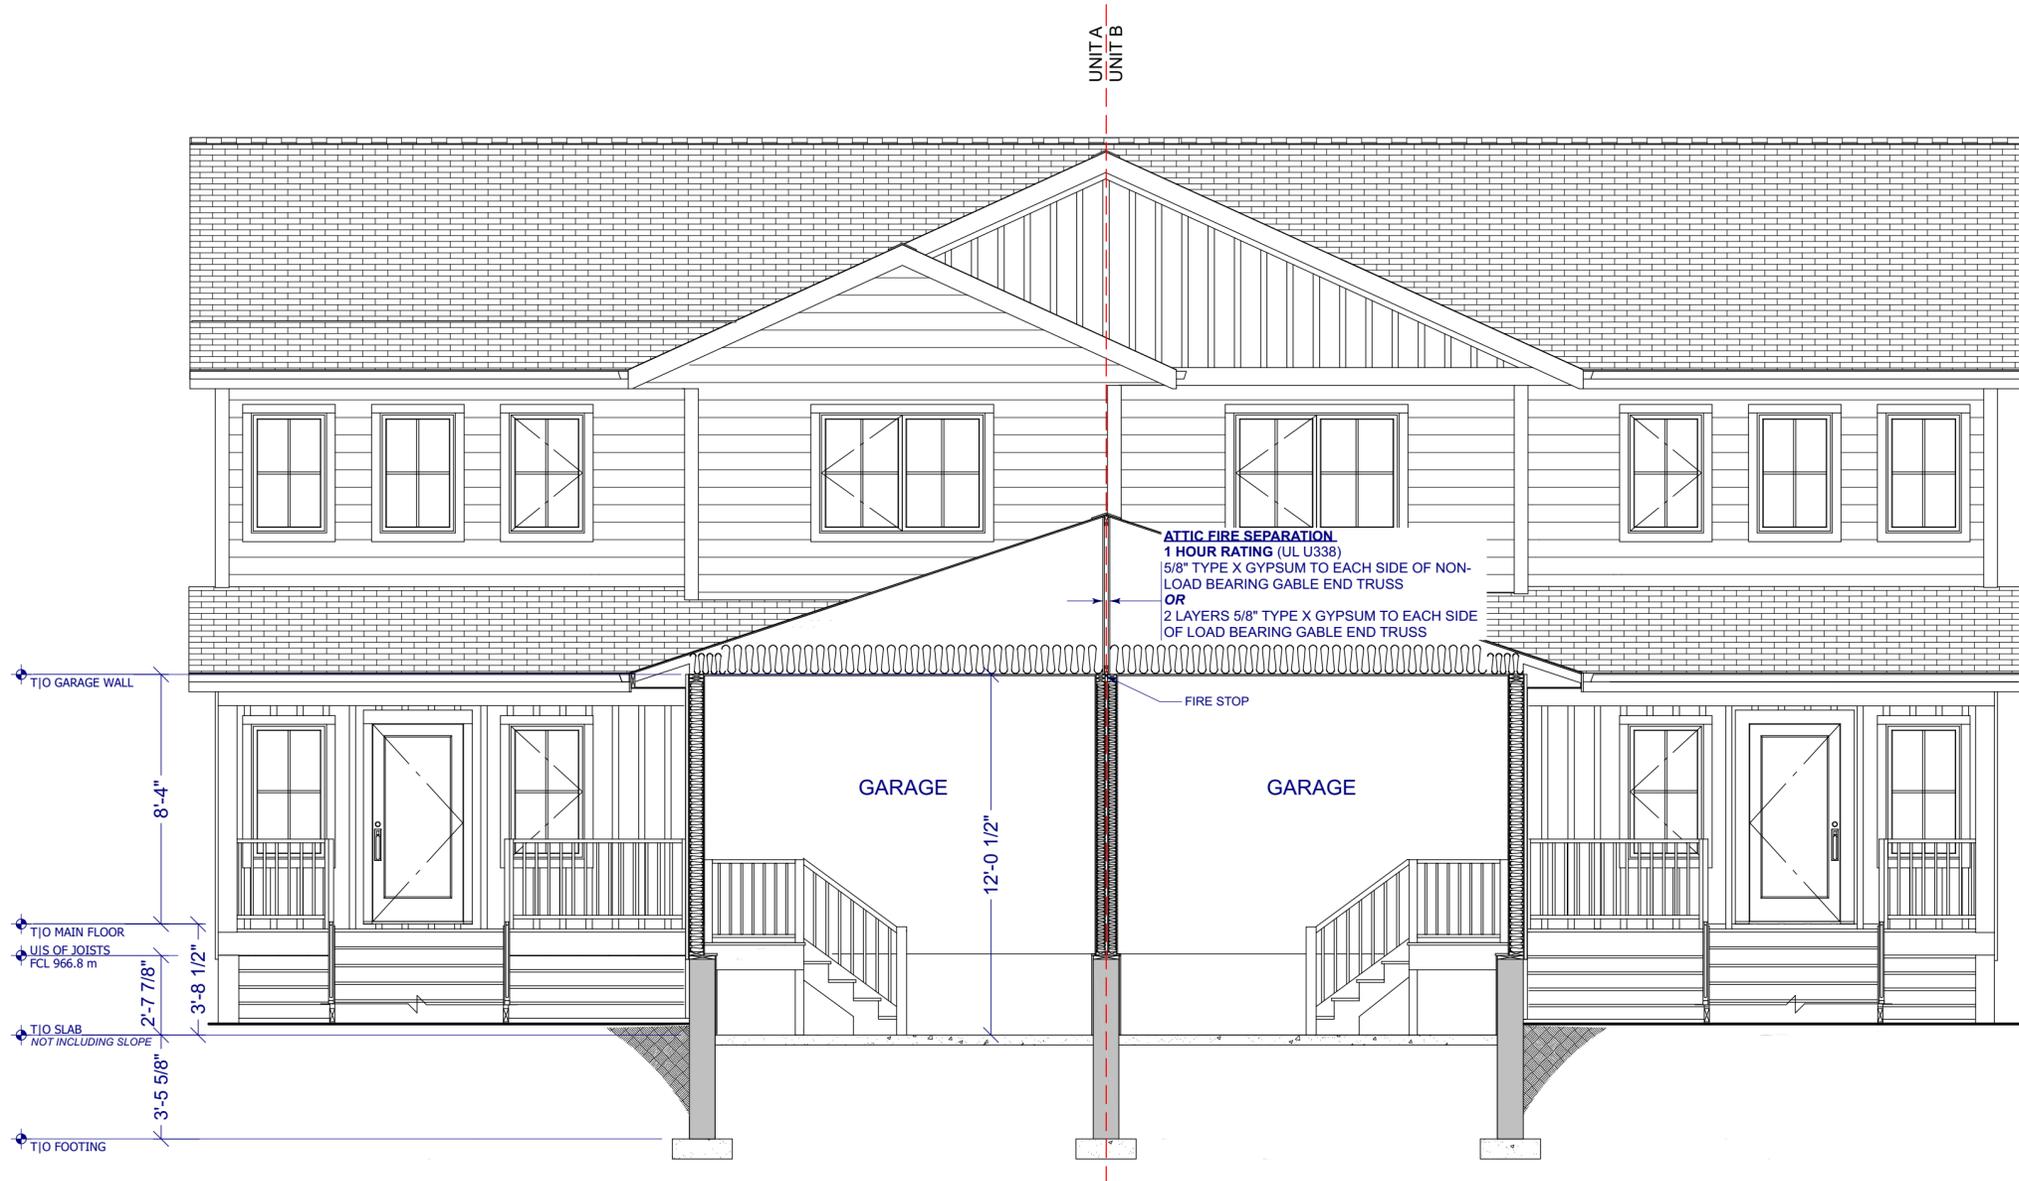

1 BUILDING SECTION III

THE INFORMATION CONTAINED ON THIS DRAWING HAS BEEN PREPARED FOR THE SOLE PURPOSE OF THE PROJECT DESCRIBED HEREIN AND FOR THE SOLE BENEFIT OF THE OWNER. USE OF THIS INFORMATION FOR ANY PURPOSE OTHER THAN THE PROJECT DESCRIBED HEREIN IS AT THE SOLE RISK OF THE USER. ANY UNAUTHORIZED USE OF THIS INFORMATION WILL BE CONSIDERED A BREACH OF COPYRIGHT AND MAY BE PURSUED AS SUCH.



TIMBERS
home + building design

T 250 489 9022 | E kim@timbershbd.com

CLIENT

GRIFFITHS
DUPLEX

PROJECT ADDRESS
980 HAND STREET
FERNIE, BC

LEGAL ADDRESS
LOT 1/A, PLAN NEP15240,
DL 5455, KOOTENAY DISTRICT
PID: 009-503-340

DRAWING

BUILDING SECTION III

7		
6		
5		
4		
3		
2		

1	ISSUE FOR REVIEW	11	KD
No	REVISION	DATE	BY

DATE
11-MAR-24


SCALE
1/4" = 1'-0"

A3.5

ISSUE FOR REVIEW

GENERAL NOTES

- PLEASE READ CAREFULLY BEFORE BEGINNING PROJECT
1. WHILE EVERY ATTEMPT HAS BEEN MADE IN THE PREPARATION OF THIS PLAN TO AVOID MISTAKES, THE DESIGNER CANNOT GUARANTEE AGAINST HUMAN ERROR.
 2. THE DESIGNER IS UNABLE TO ACCEPT ANY LIABILITY FOR THE ACCURACY OR OVERALL INTEGRITY OF THESE DRAWINGS.
 3. DRAWINGS ARE NOT TO BE SCALED.
 4. ALL DRAWINGS, DIMENSIONS, DETAILS, AND NOTES TO BE REVIEWED AND CONFIRMED BY THE GENERAL CONTRACTOR BEFORE UNDERTAKING ANY WORK ON THE PROJECT. ANY DISCREPANCIES, ERRORS OR OMISSIONS TO BE REPORTED TO THE DESIGNER IMMEDIATELY BEFORE ORDERING MATERIALS OR COMMENCING CONSTRUCTION.
 5. DESIGNER IS NOT RESPONSIBLE FOR ERRORS AND OMISSIONS IN STRUCTURAL DESIGN. ALL STRUCTURAL SYSTEMS TO BE ENGINEERED BY OTHERS. STRUCTURAL LOCATIONS AND SIZES OF SONOTUBES, COLUMNS, FOOTINGS, AND BEAMS ARE A GUIDE ONLY. THEY MUST BE VERIFIED BY TRUSS / FLOOR MANUFACTURER BEFORE CONSTRUCTION BEGINS.
 6. ALL SITE DIMENSIONS AND MEASUREMENTS ARE TO BE GOVERNED AND APPROVED BY MUNICIPAL AUTHORITIES BEFORE STARTING CONSTRUCTION.
 7. ALL CONSTRUCTION TO COMPLY WITH CURRENT BUILDING CODE, REGULATIONS, RULES AND BYLAWS SET BY THE AUTHORITY HAVING JURISDICTION.
 8. ALL CONSTRUCTION TO COMPLY WITH INDUSTRY TRADE STANDARDS AND MANUFACTURER'S RECOMMENDATIONS WHERE THOSE INSTRUCTIONS AND RECOMMENDATIONS ARE MORE STRINGENT THAN THAT CONTAINED ON THE DRAWING. ALL MATERIALS AND ENGINEERED COMPONENTS TO BE INSTALLED TO MANUFACTURER'S SPECIFICATIONS AND AS PER ENGINEERED DRAWINGS.
 9. FOUNDATION AND FOOTING DESIGN ARE TYPICAL. ONLY AND ASSUME STANDARD SOIL CONDITIONS AS OUTLINED IN THE BC BUILDING CODE, LATEST EDITION. IT IS THE RESPONSIBILITY OF THE OWNER / GENERAL CONTRACTOR TO CONFIRM SITE CONDITIONS AND PROVIDE ENGINEERING IF REQUIRED.
 10. GENERAL CONTRACTOR TO CONFIRM FOUNDATION WALLS MEET THE REQUIRED BACKFILL HEIGHTS, SPECIFIED WALLS AND GRADES TO BE ADJUSTED TO SUIT SITE CONDITIONS. EXTERIOR GRADE & ALL ELEMENTS AFFECTED BY FINAL GRADE ARE TO BE CONFIRMED PRIOR TO CONSTRUCTION (BY OTHER).
 11. ALL WOOD FRAMING TO BE SFF #2 OR BETTER. ANY LUMBER IN CONTACT WITH CONCRETE MUST BE "PRESERVED WOOD FOUNDATION" (PW) MATERIAL.
 12. ALL LOADING & DRIFTING ARE TO BE DESIGNED BY OTHERS.
 13. PLUMBING, ELECTRICAL & HEATING BY CONTRACTOR TO CODE, LATEST EDITION.
 14. ROOF VENTS INSTALLED IN ACCORDANCE WITH THE BC BUILDING CODE 9.19.1.
 15. IN-FLOOR HEATED CONCRETE SYSTEM BY OTHERS. PROVISIONS TO BE MADE FOR SOIL GAS CONTROL AS PER BC BUILDING CODE 9.13.4.
 17. STAIRS AND HANDRAILS INSTALLED IN ACCORDANCE WITH THE BC BUILDING CODE 9.8.
 18. DOOR AND WINDOW SIZES ARE APPROXIMATE AND MAY VARY BETWEEN MANUFACTURERS. ACTUAL SIZES AND ROUGH OPENINGS TO BE OBTAINED FROM SUPPLIER. ALL DOORS & WINDOWS MUST BE MARK COMPLIANT WHERE APPLICABLE AND IN ACCORDANCE WITH BC BUILDING CODE. DOORS BETWEEN HOUSE AND GARAGE TO HAVE SELF-CLOSING MECHANISM AND WEATHER STRIPPING. FIRE RATED DOORS / w SELF CLOSURES TO BE INSTALLED IN ALL FIRE RATED WALLS.
 19. INFORMATION ON THESE DRAWINGS ASSUME THE AREA OF DOORS AND WINDOWS DO NOT EXCEED THE MAXIMUM RATIO TO WALL AREA OF 25% UNLESS NOTED OTHERWISE.
 20. WALLS GREATER THAN 12'-0" IN HEIGHT TO COMPLY WITH THE LOCAL JURISDICTION'S GLUE FOR TALL WALLS (WHERE APPLICABLE) OR BE ENGINEERED.
 21. WORKING DRAWINGS ARE A GRAPHIC REPRESENTATION ONLY - ACTUAL PRODUCTS AND MATERIALS USED MAY VARY FROM THE DEPICTION ON DRAWING.
 22. ENGINEERS DRAWINGS AND/OR STAMP AS REQUIRED SHALL BE THE RESPONSIBILITY OF THE GENERAL CONTRACTOR AND/OR THE OWNER.
 23. ANYTHING NOT COVERED IN THE PLANS WILL BE OPEN FOR NEGOTIATION BETWEEN THE OWNER AND THE GENERAL CONTRACTOR.

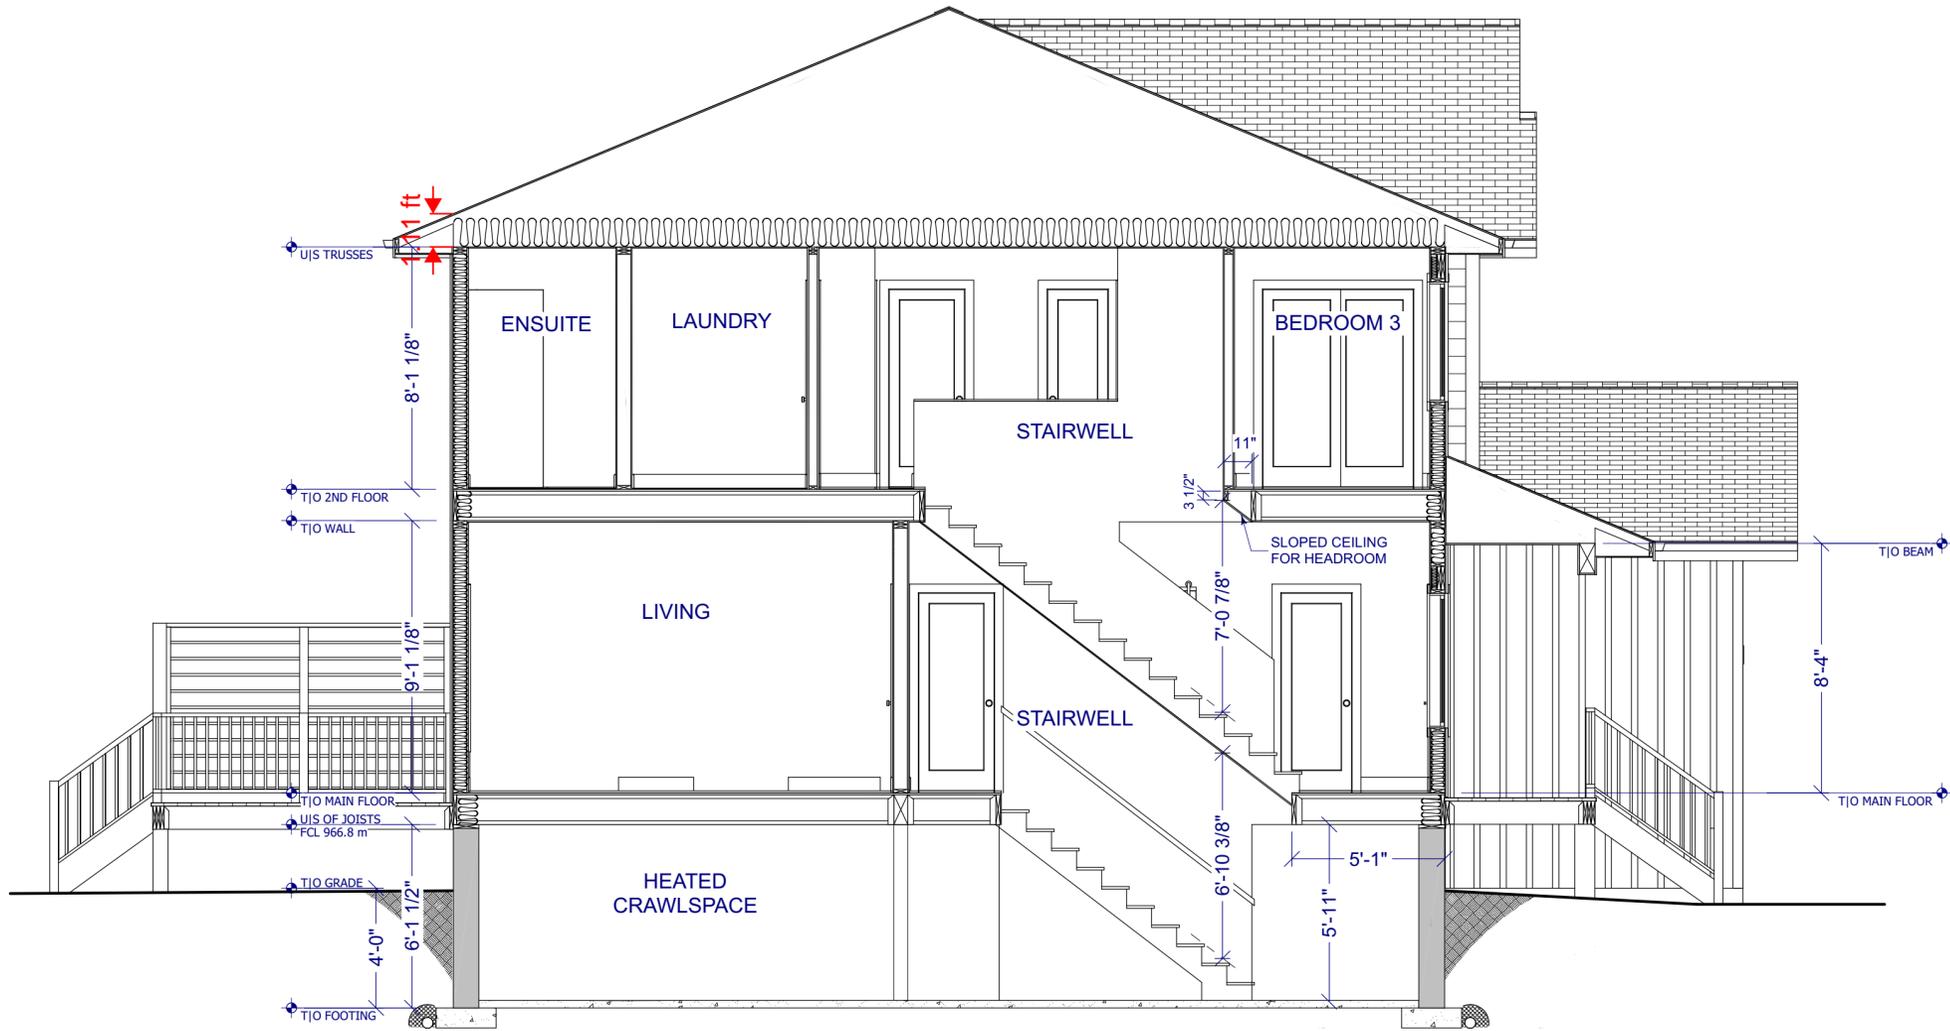

1 BUILDING SECTION IV

THE INFORMATION CONTAINED ON THIS DRAWING HAS BEEN PREPARED FOR THE SOLE PURPOSE OF THE PROJECT DESCRIBED HEREIN AND FOR THE SOLE BENEFIT OF THE OWNER. USE OF THIS INFORMATION FOR ANY PURPOSE OTHER THAN THE PROJECT DESCRIBED HEREIN IS AT THE SOLE RISK OF THE USER. ANY UNAUTHORIZED USE OF THIS INFORMATION WILL BE CONSIDERED A BREACH OF COPYRIGHT AND MAY BE PURSUED AS SUCH.



TIMBERS
home + building design

T 250 489 9022 | E kim@timbershbd.com

CLIENT

GRIFFITHS
DUPLEX

PROJECT ADDRESS
980 HAND STREET
FERNIE, BC

LEGAL ADDRESS
LOT 1/A, PLAN NEP15240,
DL 5455, KOOTENAY DISTRICT
PID: 009-503-340

DRAWING
BUILDING SECTION IV

7			
6			
5			
4			
3			
2			
1	ISSUE FOR REVIEW	11 MAR	KD
No	REVISION	DATE	BY

DATE
11-MAR-24

PAGE No.
A3.6

SCALE
1/4" = 1'-0"

ISSUE FOR REVIEW

ELECTRICAL LEGEND	
	CEILING FAN
	CEILING FIXTURE / PENDANT
	RECESSED POT LIGHT
	VANITY LIGHT
	EXTERIOR COACH LIGHT / INTERIOR WALL SCONCE
	TUBE FIXTURE
	UNDER CABINET LIGHTING
	110v OUTLET
	110v WEATHERPROOF OUTLET
	110v GFCI OUTLET
	110v SPLIT WIRED OUTLET
	220v OUTLET
	APPLIANCE SPECIFIC OUTLETS
	USB OUTLET
	STANDARD SWITCH
	3 WAY / 4 WAY SWITCH
	DIMMER SWITCH
	CAT 6 JACK
	TV JACK
	TELEPHONE JACK
	SMOKE DETECTOR
	CARBON MONOXIDE / SMOKE DETECTOR
	EXHAUST FAN


CRAWLSPACE AREA
1590 sq ft

MECHANICAL & ELECTRICAL NOTES

- VARIABLE SPEED FURNACE (1 PER SIDE)
- POWER VENT HOT WATER TANK (1 PER SIDE)
- AIR CONDITIONER (1 PER SIDE)
- HRV (1 PER SIDE)
- 200 AMP ELECTRICAL SERVICE (1 PER SIDE)
- CONDUIT FOR FUTURE EV CHARGERS (GARAGES)
- ELECTRIC FIREPLACE (LIVING ROOMS)
- GAS BBQ OUTLET (REAR DECK)
- IRRIGATION ROUGH-IN
- WATERLINE TO FRIDGE
- TV OUTLET (LIVING, LOFTS, MASTER BEDROOMS)
- CAT 6 (OFFICES)

STRUCTURAL NOTE

SEE P.ENG | ENGINEERED DRAWINGS FOR ALL STRUCTURAL ELEMENTS OF DESIGN, INCLUDING FOUNDATION WALLS, BEAMS, COLUMNS, JOISTS, TRUSSES AND LINTELS. PAD FOOTING SIZES SUPPORTING ROOF LOAD TO BE CONFIRMED BY OTHER.

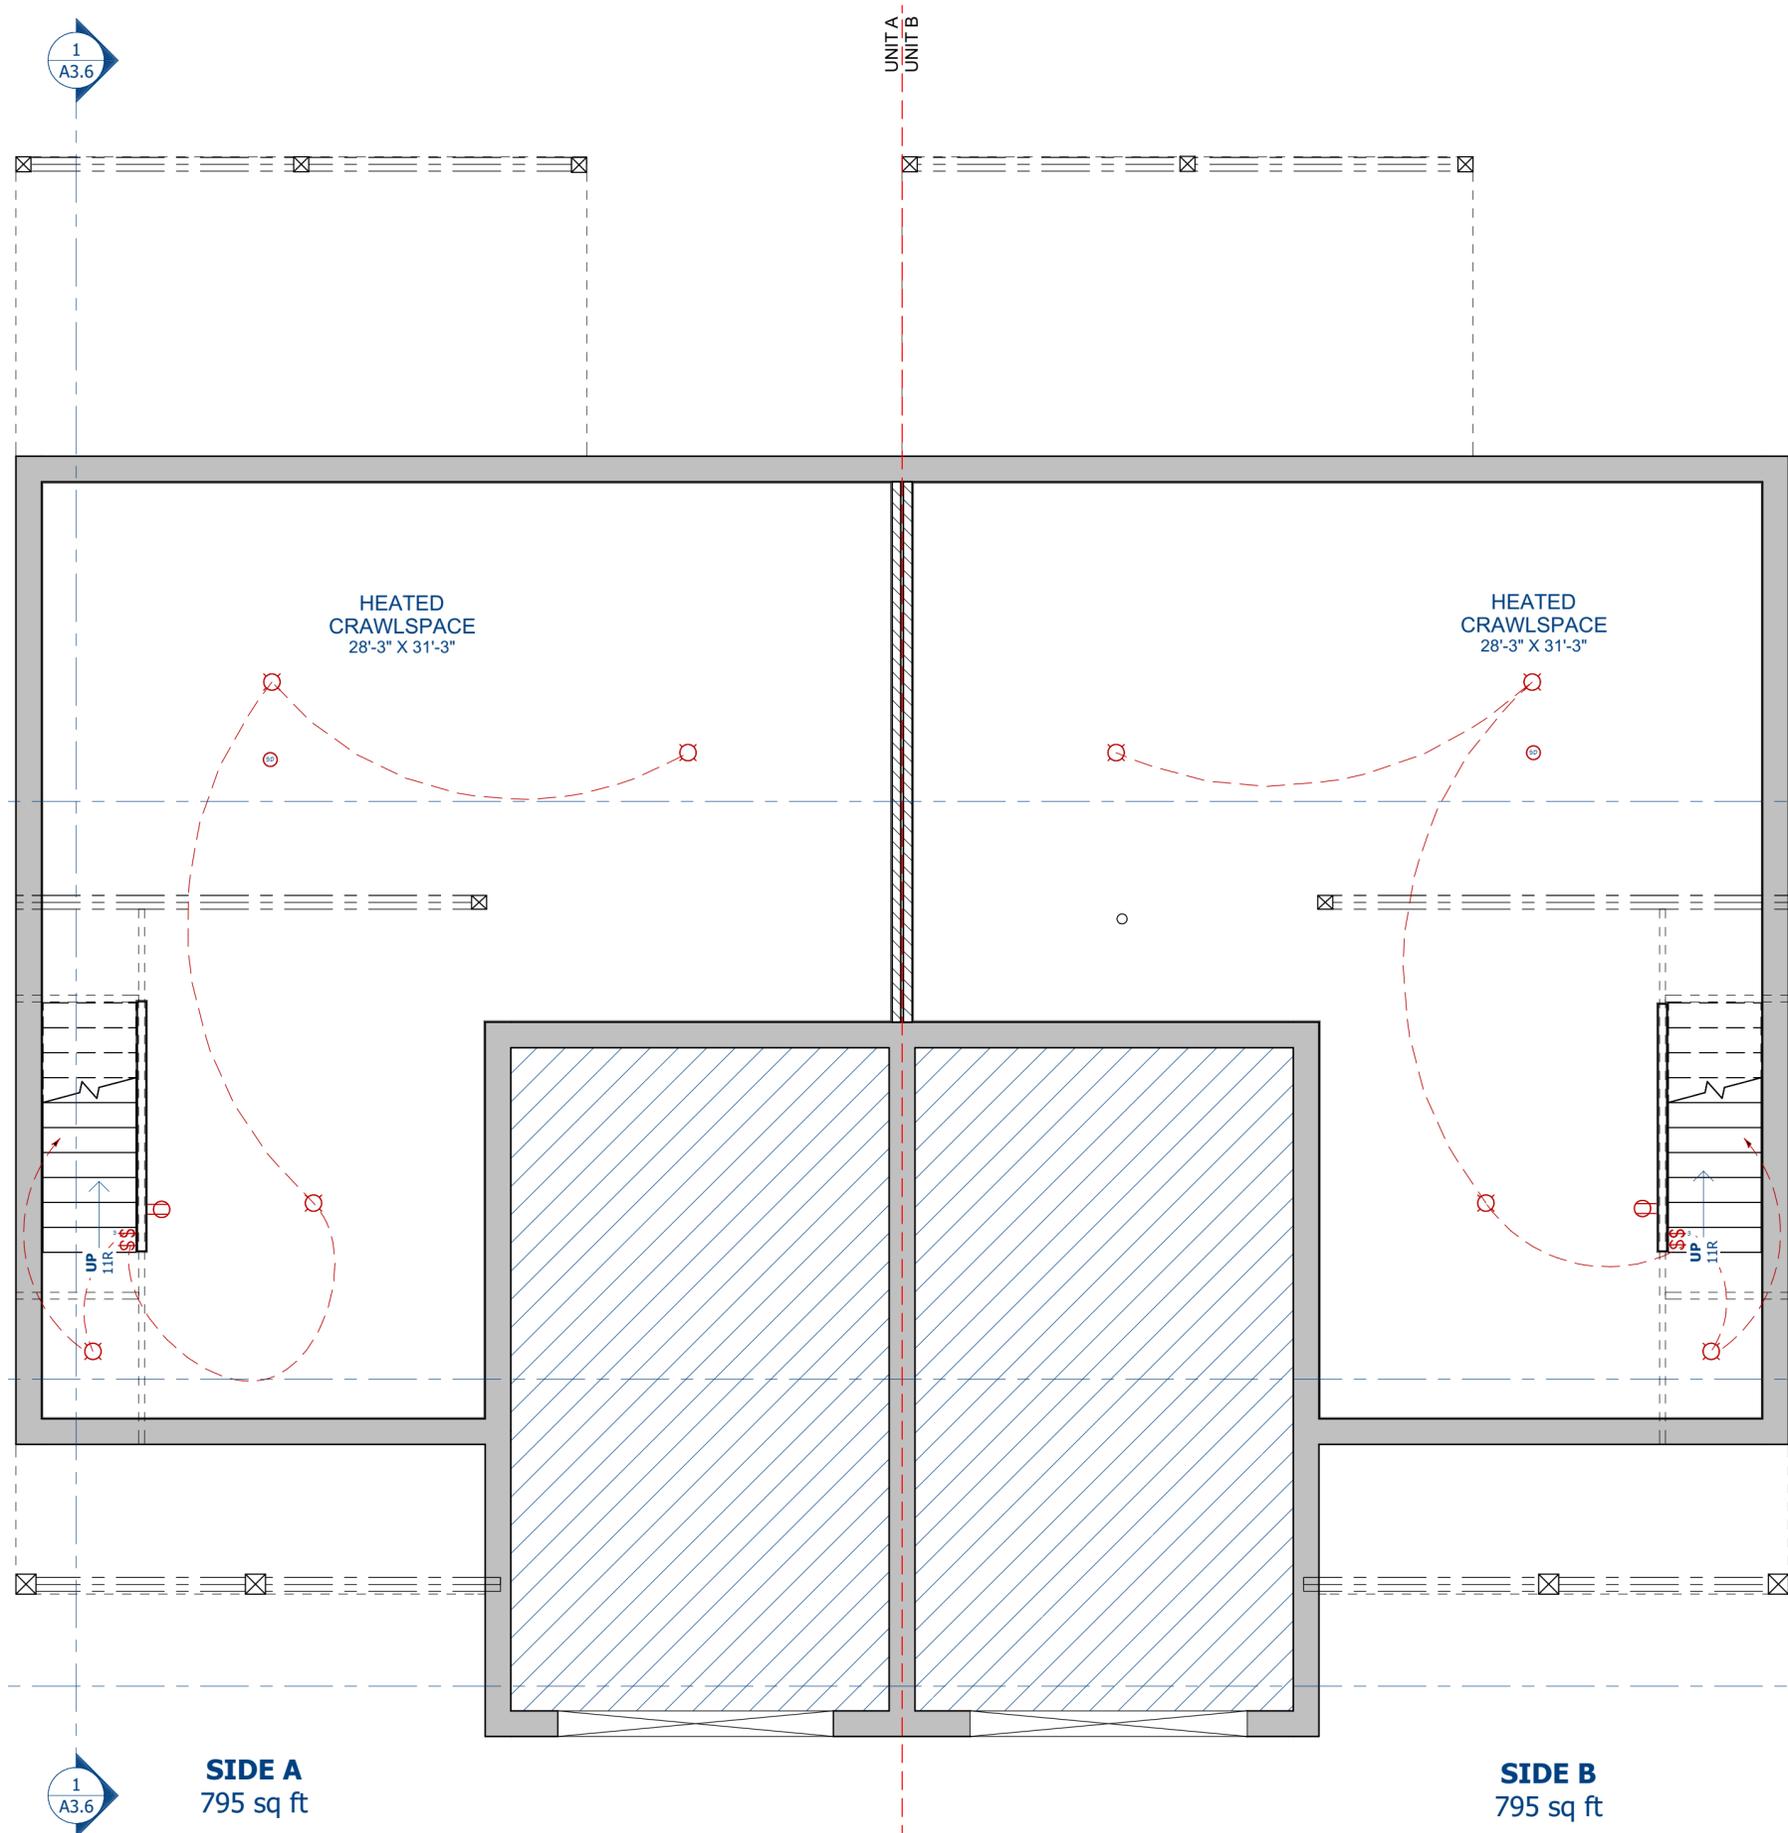

GENERAL NOTES

- PLEASE READ CAREFULLY BEFORE BEGINNING PROJECT
- WHILE EVERY ATTEMPT HAS BEEN MADE IN THE PREPARATION OF THIS PLAN TO AVOID MISTAKES, THE DESIGNER CANNOT GUARANTEE AGAINST HUMAN ERROR.
 - THE DESIGNER IS UNABLE TO ACCEPT ANY LIABILITY FOR THE ACCURACY OR OVERALL INTEGRITY OF THESE DRAWINGS.
 - DRAWINGS ARE NOT TO BE SCALED.
 - ALL DRAWINGS, DIMENSIONS, DETAILS, AND NOTES TO BE REVIEWED AND CONFIRMED BY THE GENERAL CONTRACTOR BEFORE UNDERTAKING ANY WORK ON THE PROJECT. ANY DISCREPANCIES, ERRORS OR OMISSIONS TO BE REPORTED TO THE DESIGNER IMMEDIATELY BEFORE ORDERING MATERIALS OR COMMENCING CONSTRUCTION.
 - DESIGNER IS NOT RESPONSIBLE FOR ERRORS AND OMISSIONS IN STRUCTURAL DESIGN. ALL STRUCTURAL SYSTEMS TO BE ENGINEERED BY OTHERS. STRUCTURAL LOCATIONS AND SIZES OF SONOTUBES, COLUMNS, FOOTINGS, AND BEAMS ARE A GUIDE ONLY; THEY MUST BE VERIFIED BY TRUSS / FLOOR MANUFACTURER BEFORE CONSTRUCTION BEGINS.
 - ALL SITE DIMENSIONS AND MEASUREMENTS ARE TO BE GOVERNED AND APPROVED BY MUNICIPAL AUTHORITIES BEFORE STARTING CONSTRUCTION.
 - ALL CONSTRUCTION TO COMPLY WITH CURRENT BUILDING CODE, REGULATIONS, RULES AND BYLAWS SET BY THE AUTHORITY HAVING JURISDICTION.
 - ALL CONSTRUCTION TO COMPLY WITH INDUSTRY TRADE STANDARDS AND MANUFACTURER'S RECOMMENDATIONS WHERE THESE INSTRUCTIONS AND RECOMMENDATIONS ARE MORE STRINGENT THAN THAT CONTAINED ON THE DRAWING. ALL MATERIALS AND ENGINEERED COMPONENTS TO BE INSTALLED TO MANUFACTURER'S SPECIFICATIONS AND AS PER ENGINEERED DRAWINGS.
 - FOUNDATION AND FOOTING DESIGN ARE TYPICAL, ONLY AND ASSUME STANDARD SOIL CONDITIONS AS OUTLINED IN THE BC BUILDING CODE, LATEST EDITION. IT IS THE RESPONSIBILITY OF THE OWNER | GENERAL CONTRACTOR TO CONFIRM SITE CONDITIONS AND PROVIDE ENGINEERING IF REQUIRED.
 - GENERAL CONTRACTOR TO CONFIRM FOUNDATION WALLS MEET THE REQUIRED BACKFILL HEIGHTS, SPECIFIED WALLS AND GRADES TO BE ADJUSTED TO SUIT SITE CONDITIONS. EXTERIOR GRADES & ALL ELEMENTS AFFECTED BY FINAL GRADE ARE TO BE CONFIRMED PRIOR TO CONSTRUCTION (BY OTHER).
 - ALL WOOD FRAMING TO BE SPF #2 OR BETTER. ANY LUMBER IN CONTACT WITH CONCRETE MUST BE "PRESERVED WOOD FOUNDATION" (PW) MATERIAL.
 - ALL LOADING & DRIFTING ARE TO BE DESIGNED BY OTHERS.
 - PLUMBING, ELECTRICAL & HEATING BY CONTRACTOR TO CODE, LATEST EDITION.
 - ROOF VENTS INSTALLED IN ACCORDANCE WITH THE BC BUILDING CODE 9.13.1.
 - IN-FLOOR HEATED CONCRETE SYSTEM BY OTHERS. PROVISIONS TO BE MADE FOR SOIL GAS CONTROL AS PER BC BUILDING CODE 9.13.4.
 - STAIRS AND HANDRAILS INSTALLED IN ACCORDANCE WITH THE BC BUILDING CODE 9.8.
 - DOOR AND WINDOW SIZES ARE APPROXIMATE AND MUST BE MARK COMPLIANT WHERE APPLICABLE AND IN ACCORDANCE WITH BC BUILDING CODE. DOORS BETWEEN HOUSE AND GARAGE TO HAVE SELF-CLOSING MECHANISM AND WEATHER STRIPPING. FIRE RATED DOORS / w SELF CLOSURES TO BE INSTALLED IN ALL FIRE RATED WALLS.
 - INFORMATION ON THESE DRAWINGS ASSUME THE AREA OF DOORS AND WINDOWS DO NOT EXCEED THE MAXIMUM RATIO TO WALL AREA OF 25% UNLESS NOTED OTHERWISE.
 - WALLS GREATER THAN 12'-0" IN HEIGHT TO COMPLY WITH THE LOCAL JURISDICTION'S GLUE FOR TALL WALLS (WHERE APPLICABLE) OR BE ENGINEERED.
 - WORKING DRAWINGS ARE A GRAPHIC REPRESENTATION ONLY - ACTUAL PRODUCTS AND MATERIALS USED MAY VARY FROM THE DEPICTION ON DRAWING.
 - ENGINEERS DRAWINGS AND/OR STAMP AS REQUIRED SHALL BE THE RESPONSIBILITY OF THE GENERAL CONTRACTOR AND/OR THE OWNER.
 - ANYTHING NOT COVERED IN THE PLANS WILL BE OPEN FOR NEGOTIATION BETWEEN THE OWNER AND THE GENERAL CONTRACTOR.

THE INFORMATION CONTAINED ON THIS DRAWING HAS BEEN PREPARED FOR THE SOLE PURPOSE OF THE PROJECT DESCRIBED HEREIN AND FOR THE SOLE BENEFIT OF THE OWNER. USE OF THIS INFORMATION FOR ANY PURPOSE OTHER THAN THE PROJECT DESCRIBED HEREIN IS AT THE SOLE RISK OF THE USER. ANY UNAUTHORIZED USE OF THIS INFORMATION WILL BE CONSIDERED A BREACH OF COPYRIGHT AND MAY BE PURSUED AS SUCH.

TIMBERS
home + building design
T 250 489 9022 | E kim@timbershbd.com

GRIFFITHS
DUPLEX

PROJECT ADDRESS
980 HAND STREET
FERNIE, BC

LEGAL ADDRESS
LOT 1/A, PLAN NEP15240,
DL 5455, KOOTENAY DISTRICT
PID: 009-503-340

DRAWING
CRAWLSPACE ELECTRICAL PLAN

7			
6			
5			
4			
3			
2			
1	ISSUE FOR REVIEW	11 MAR	KD
No.	REVISION	DATE	BY
DATE	PAGE No.		
11-MAR-24	E1.1		
SCALE	1/4" = 1'-0"		

ISSUE FOR REVIEW

1 CRAWLSPACE ELECTRICAL PLAN


ELECTRICAL LEGEND	
	CEILING FAN
	CEILING FIXTURE / PENDANT
	RECESSED POT LIGHT
	VANITY LIGHT
	EXTERIOR COACH LIGHT INTERIOR WALL SCONCE
	TUBE FIXTURE
	UNDER CABINET LIGHTING
	110v OUTLET
	110v WEATHERPROOF OUTLET
	110v GFCI OUTLET
	110v SPLIT WIRED OUTLET
	220v OUTLET
	APPLIANCE SPECIFIC OUTLETS
	USB OUTLET
	STANDARD SWITCH
	3 WAY / 4 WAY SWITCH
	DIMMER SWITCH
	CAT 6 JACK
	TV JACK
	TELEPHONE JACK
	SMOKE DETECTOR
	CARBON MONOXIDE / SMOKE DETECTOR
	EXHAUST FAN

LIVING AREA
1590 sq ft

- MECHANICAL & ELECTRICAL NOTES**
- VARIABLE SPEED FURNACE (1 PER SIDE)
 - POWER VENT HOT WATER TANK (1 PER SIDE)
 - AIR CONDITIONER (1 PER SIDE)
 - HRV (1 PER SIDE)
 - 200 AMP ELECTRICAL SERVICE (1 PER SIDE)
 - CONDUIT FOR FUTURE EV CHARGERS (GARAGES)
 - ELECTRIC FIREPLACE (LIVING ROOMS)
 - GAS BBQ OUTLET (REAR DECK)
 - IRRIGATION ROUGH-IN
 - WATERLINE TO FRIDGE
 - TV OUTLET (LIVING, LOFTS, MASTER BEDROOMS)
 - CAT 6 (OFFICES)

STRUCTURAL NOTE

SEE PENG | ENGINEERED DRAWINGS FOR ALL STRUCTURAL ELEMENTS OF DESIGN, INCLUDING FOUNDATION WALLS, BEAMS, COLUMNS, JOISTS, TRUSSES AND LINTELS. PAD FOOTING SIZES SUPPORTING ROOF LOAD TO BE CONFIRMED BY OTHER.

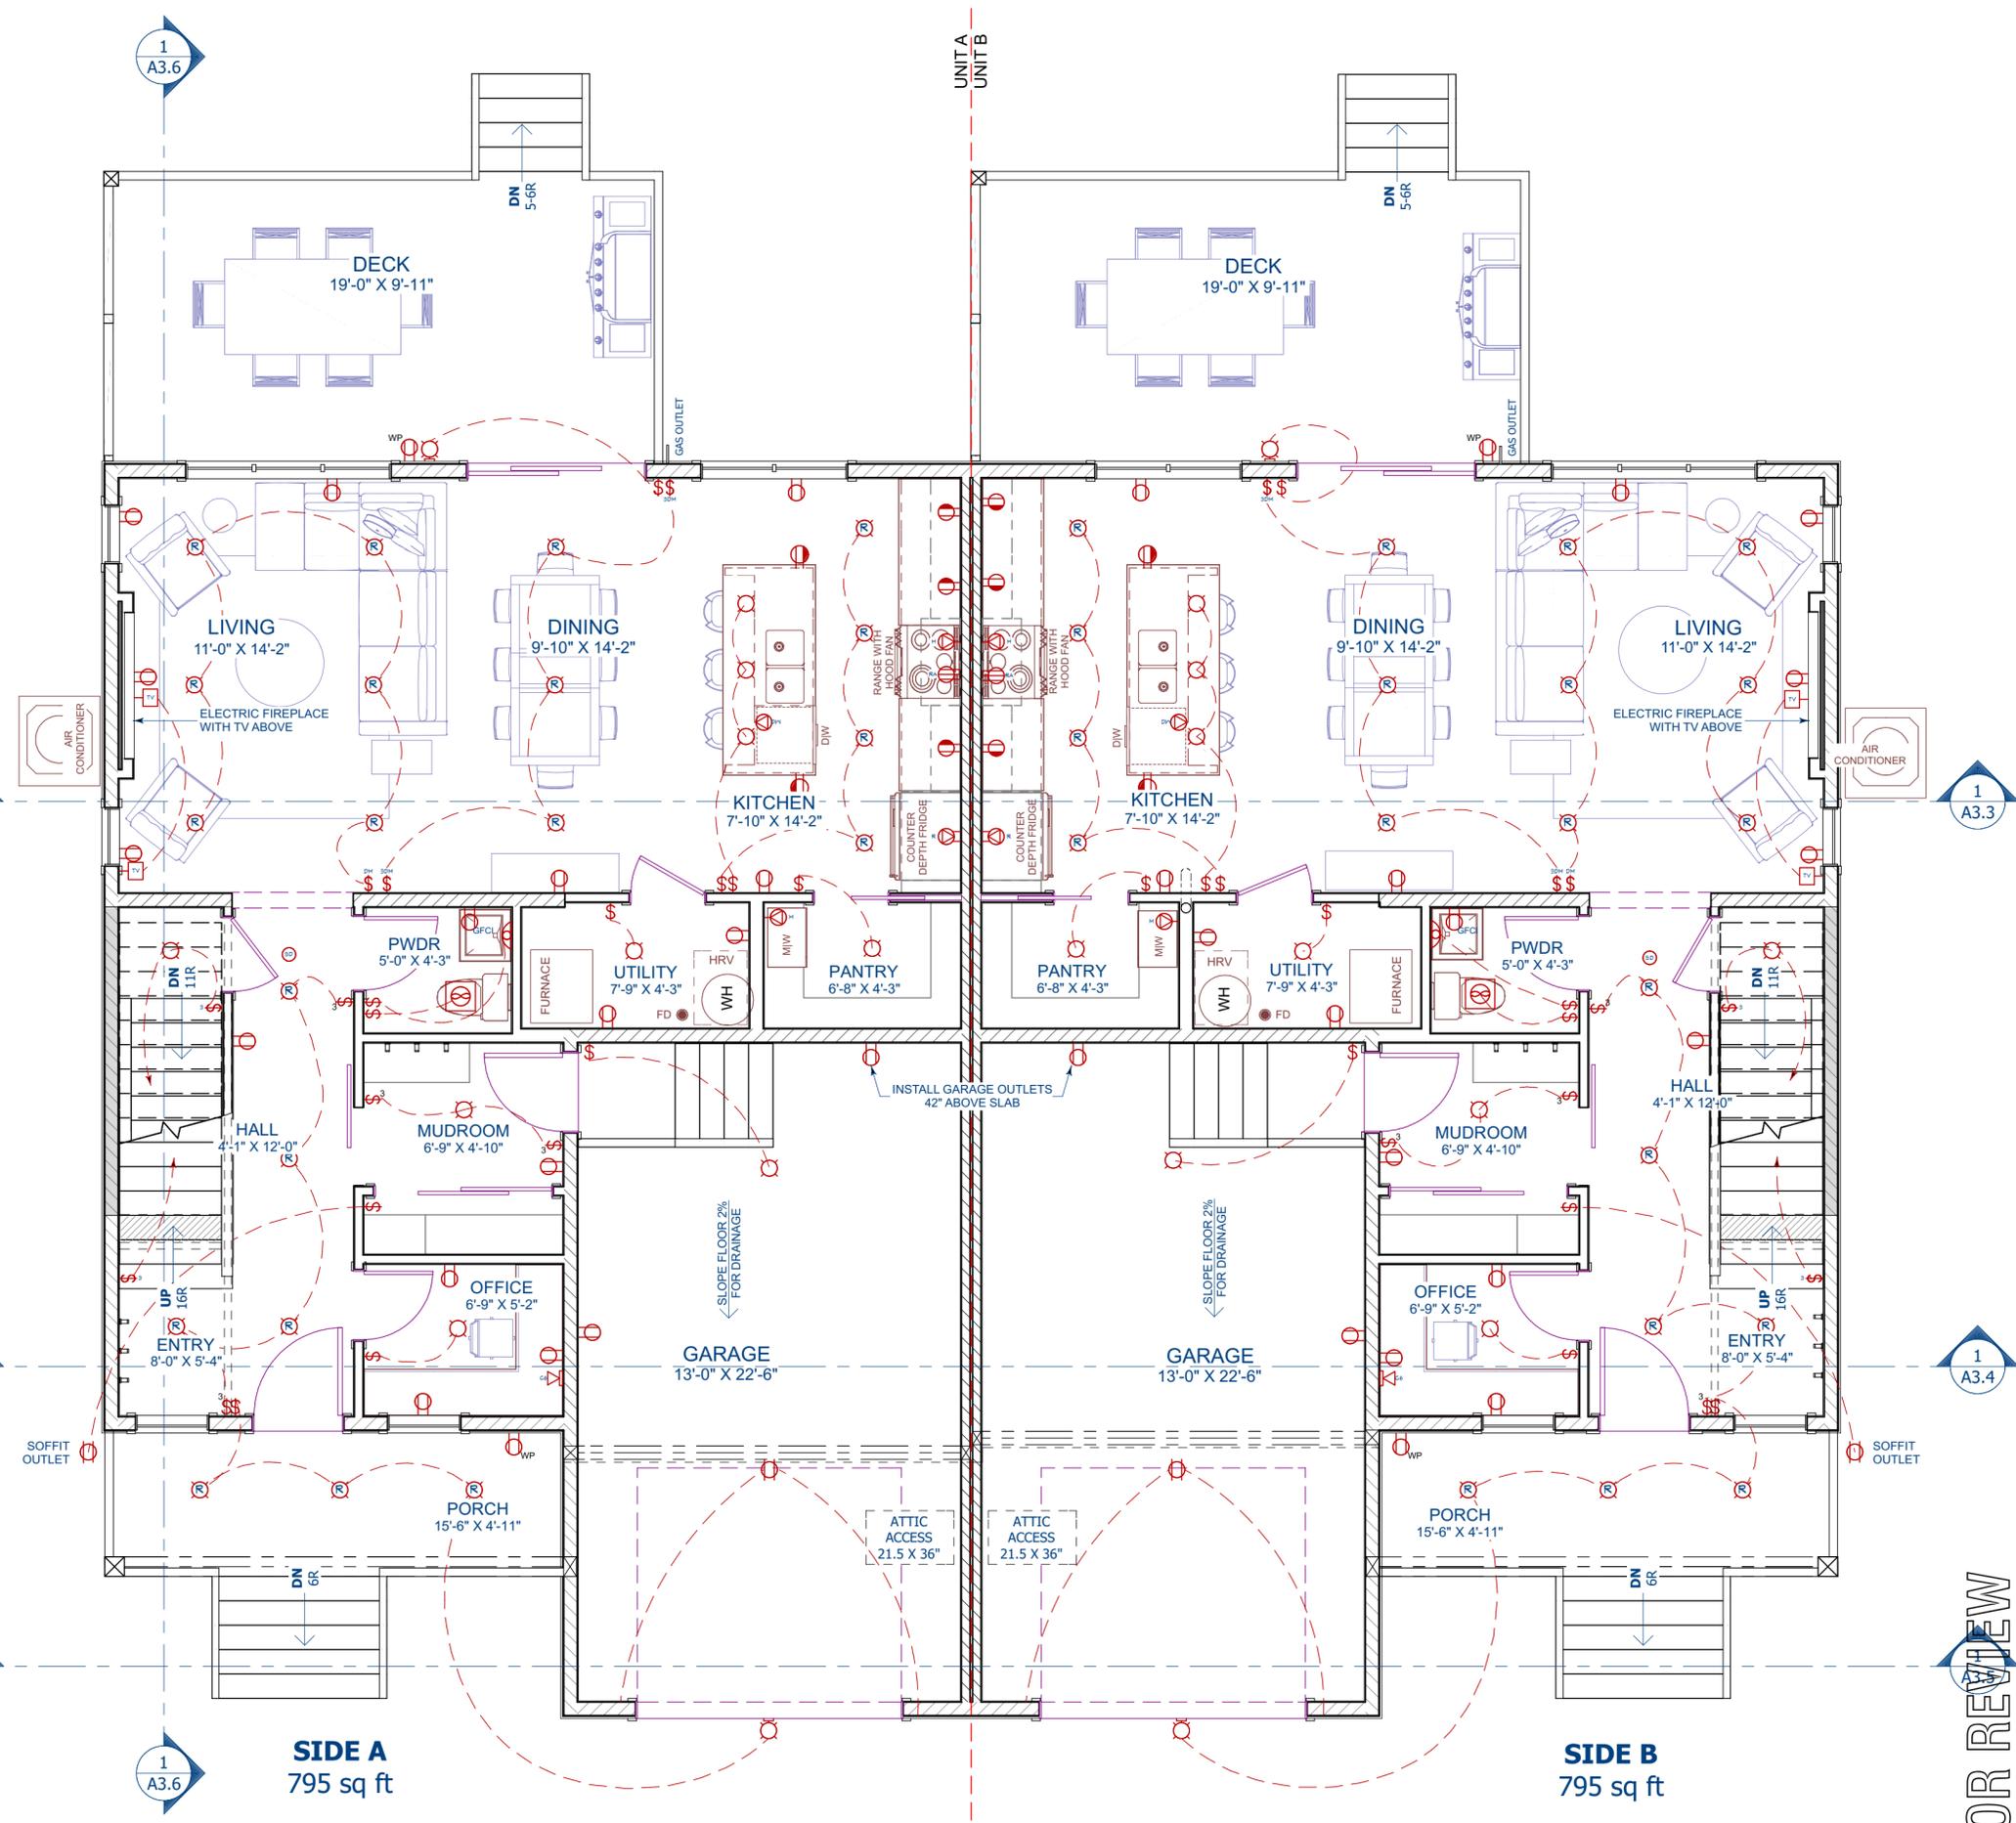

- GENERAL NOTES**
- PLEASE READ CAREFULLY BEFORE BEGINNING PROJECT
- WHILE EVERY ATTEMPT HAS BEEN MADE IN THE PREPARATION OF THIS PLAN TO AVOID MISTAKES, THE DESIGNER CANNOT GUARANTEE AGAINST HUMAN ERROR.
 - THE DESIGNER IS UNABLE TO ACCEPT ANY LIABILITY FOR THE ACCURACY OR OVERALL INTEGRITY OF THESE DRAWINGS.
 - DRAWINGS ARE NOT TO BE SCALED.
 - ALL DRAWINGS, DIMENSIONS, DETAILS, AND NOTES TO BE REVIEWED AND CONFIRMED BY THE GENERAL CONTRACTOR BEFORE UNDERTAKING ANY WORK ON THE PROJECT. ANY DISCREPANCIES, ERRORS OR OMISSIONS TO BE REPORTED TO THE DESIGNER IMMEDIATELY BEFORE ORDERING MATERIALS OR COMMENCING CONSTRUCTION.
 - DESIGNER IS NOT RESPONSIBLE FOR ERRORS AND OMISSIONS IN STRUCTURAL DESIGN. ALL STRUCTURAL SYSTEMS TO BE ENGINEERED BY OTHERS. STRUCTURAL LOCATIONS AND SIZES OF SONOTUBES, COLUMNS, FOOTINGS, AND BEAMS ARE A GUIDE ONLY; THEY MUST BE VERIFIED BY TRUSS / FLOOR MANUFACTURER BEFORE CONSTRUCTION BEGINS.
 - ALL SITE DIMENSIONS AND MEASUREMENTS ARE TO BE GOVERNED AND APPROVED BY MUNICIPAL AUTHORITIES BEFORE STARTING CONSTRUCTION.
 - ALL CONSTRUCTION TO COMPLY WITH CURRENT BUILDING CODE, REGULATIONS, RULES AND BYLAWS SET BY THE AUTHORITY HAVING JURISDICTION.
 - ALL CONSTRUCTION TO COMPLY WITH INDUSTRY TRADE STANDARDS AND MANUFACTURER'S RECOMMENDATIONS WHERE THESE INSTRUCTIONS AND RECOMMENDATIONS ARE MORE STRINGENT THAN THAT CONTAINED ON THE DRAWING. ALL MATERIALS AND ENGINEERED COMPONENTS TO BE INSTALLED TO MANUFACTURER'S SPECIFICATIONS AND AS PER ENGINEERED DRAWINGS.
 - FOUNDATION AND FOOTING DESIGN ARE TYPICAL ONLY AND ASSUME STANDARD SOIL CONDITIONS AS OUTLINED IN THE BC BUILDING CODE, LATEST EDITION. IT IS THE RESPONSIBILITY OF THE OWNER / GENERAL CONTRACTOR TO CONFIRM SITE CONDITIONS AND PROVIDE ENGINEERING IF REQUIRED.
 - GENERAL CONTRACTOR TO CONFIRM FOUNDATION WALLS MEET THE REQUIRED BACKFILL HEIGHTS, SPECIFIED WALLS AND GRADES TO BE ADJUSTED TO SUIT SITE CONDITIONS. EXTERIOR GRADES & ALL ELEMENTS AFFECTED BY FINAL GRADE ARE TO BE CONFIRMED PRIOR TO CONSTRUCTION (BY OTHER).
 - ALL WOOD FRAMING TO BE SFF #2 OR BETTER. ANY LUMBER IN CONTACT WITH CONCRETE MUST BE "PRESERVED WOOD FOUNDATION (PW) MATERIAL".
 - ALL LOADING & DRIFTING ARE TO BE DESIGNED BY OTHERS.
 - PLUMBING, ELECTRICAL & HEATING BY CONTRACTOR TO CODE, LATEST EDITION.
 - ROOF VENTS INSTALLED IN ACCORDANCE WITH THE BC BUILDING CODE 9.19.1.
 - IN-FLOOR HEATED CONCRETE SYSTEM WITH PROVISIONS TO BE MADE FOR SOIL GAS CONTROL AS PER BC BUILDING CODE 9.13.4.
 - STAIRS AND HANDRAILS INSTALLED IN ACCORDANCE WITH THE BC BUILDING CODE 9.8.
 - DOOR AND WINDOW SIZES ARE APPROXIMATE AND MUST BE MARKED COMPLIANT WHERE APPLICABLE AND IN ACCORDANCE WITH BC BUILDING CODE. DOORS BETWEEN HOUSE AND GARAGE TO HAVE SELF-CLOSING MECHANISM AND WEATHER STRIPPING. FIRE RATED DOORS / W SELF CLOSURES TO BE INSTALLED IN ALL FIRE RATED WALLS.
 - INFORMATION ON THESE DRAWINGS ASSUME THE AREA OF DOORS AND WINDOWS DO NOT EXCEED THE MAXIMUM RATIO TO WALL AREA OF 25% UNLESS NOTED OTHERWISE.
 - WALLS GREATER THAN 12'-0" IN HEIGHT TO COMPLY WITH THE LOCAL JURISDICTION'S GLUE FOR TALL WALLS (WHERE APPLICABLE) OR BE ENGINEERED.
 - WORKING DRAWINGS ARE A GRAPHIC REPRESENTATION ONLY - ACTUAL PRODUCTS AND MATERIALS USED MAY VARY FROM THE DIRECTION ON DRAWING.
 - ENGINEERS DRAWINGS AND/OR STAMP AS REQUIRED SHALL BE THE RESPONSIBILITY OF THE GENERAL CONTRACTOR AND/OR THE OWNER.
 - ANYTHING NOT COVERED IN THE PLANS WILL BE OPEN FOR NEGOTIATION BETWEEN THE OWNER AND THE GENERAL CONTRACTOR.

THE INFORMATION CONTAINED ON THIS DRAWING HAS BEEN PREPARED FOR THE SOLE PURPOSE OF THE PROJECT DESCRIBED HEREIN AND FOR THE SOLE BENEFIT OF THE OWNER. USE OF THIS INFORMATION FOR ANY PURPOSE OTHER THAN THE PROJECT DESCRIBED HEREIN IS AT THE SOLE RISK OF THE USER. ANY UNAUTHORIZED USE OF THIS INFORMATION WILL BE CONSIDERED A BREACH OF COPYRIGHT AND MAY BE PURSUED AS SUCH.

TIMBERS
home + building design
T 250 489 9022 | E kim@timbershbs.com

GRIFFITHS
DUPLEX

PROJECT ADDRESS
980 HAND STREET
FERNIE, BC

LEGAL ADDRESS
LOT 1/A, PLAN NEP15240,
DL 5455, KOOTENAY DISTRICT
PID: 009-503-340

MAIN FLOOR ELECTRICAL PLAN

7			
6			
5			
4			
3			
2			
1	ISSUE FOR REVIEW	11 MAR	KD
No.	REVISION	DATE	BY
DATE	11-MAR-24	PAGE No.	
SCALE	1/4" = 1'-0"		E1.2

1 MAIN FLOOR ELECTRICAL PLAN


ISSUE FOR REVIEW

ELECTRICAL LEGEND	
	CEILING FAN
	CEILING FIXTURE / PENDANT
	RECESSED POT LIGHT
	VANITY LIGHT
	EXTERIOR COACH LIGHT / INTERIOR WALL SCONCE
	TUBE FIXTURE
	UNDER CABINET LIGHTING
	110v OUTLET
	110v WEATHERPROOF OUTLET
	110v GFCI OUTLET
	110v SPLIT WIRED OUTLET
	220v OUTLET
	APPLIANCE SPECIFIC OUTLETS
	USB OUTLET
	STANDARD SWITCH
	3 WAY / 4 WAY SWITCH
	DIMMER SWITCH
	CAT 6 JACK
	TV JACK
	TELEPHONE JACK
	SMOKE DETECTOR
	CARBON MONOXIDE / SMOKE DETECTOR
	EXHAUST FAN

LIVING AREA
1968 sq ft

- MECHANICAL & ELECTRICAL NOTES**
- VARIABLE SPEED FURNACE (1 PER SIDE)
 - POWER VENT HOT WATER TANK (1 PER SIDE)
 - AIR CONDITIONER (1 PER SIDE)
 - HRV (1 PER SIDE)
 - 200 AMP ELECTRICAL SERVICE (1 PER SIDE)
 - CONDUIT FOR FUTURE EV CHARGERS (GARAGES)
 - ELECTRIC FIREPLACE (LIVING ROOMS)
 - GAS BBQ OUTLET (REAR DECK)
 - IRRIGATION ROUGH-IN
 - WATERLINE TO FRIDGE
 - TV OUTLET (LIVING, LOFTS, MASTER BEDROOMS)
 - CAT 6 (OFFICES)

STRUCTURAL NOTE
SEE P.ENG | ENGINEERED DRAWINGS FOR ALL STRUCTURAL ELEMENTS OF DESIGN, INCLUDING FOUNDATION WALLS, BEAMS, COLUMNS, JOISTS, TRUSSES AND LINTELS. PAD FOOTING SIZES SUPPORTING ROOF LOAD TO BE CONFIRMED BY OTHER.

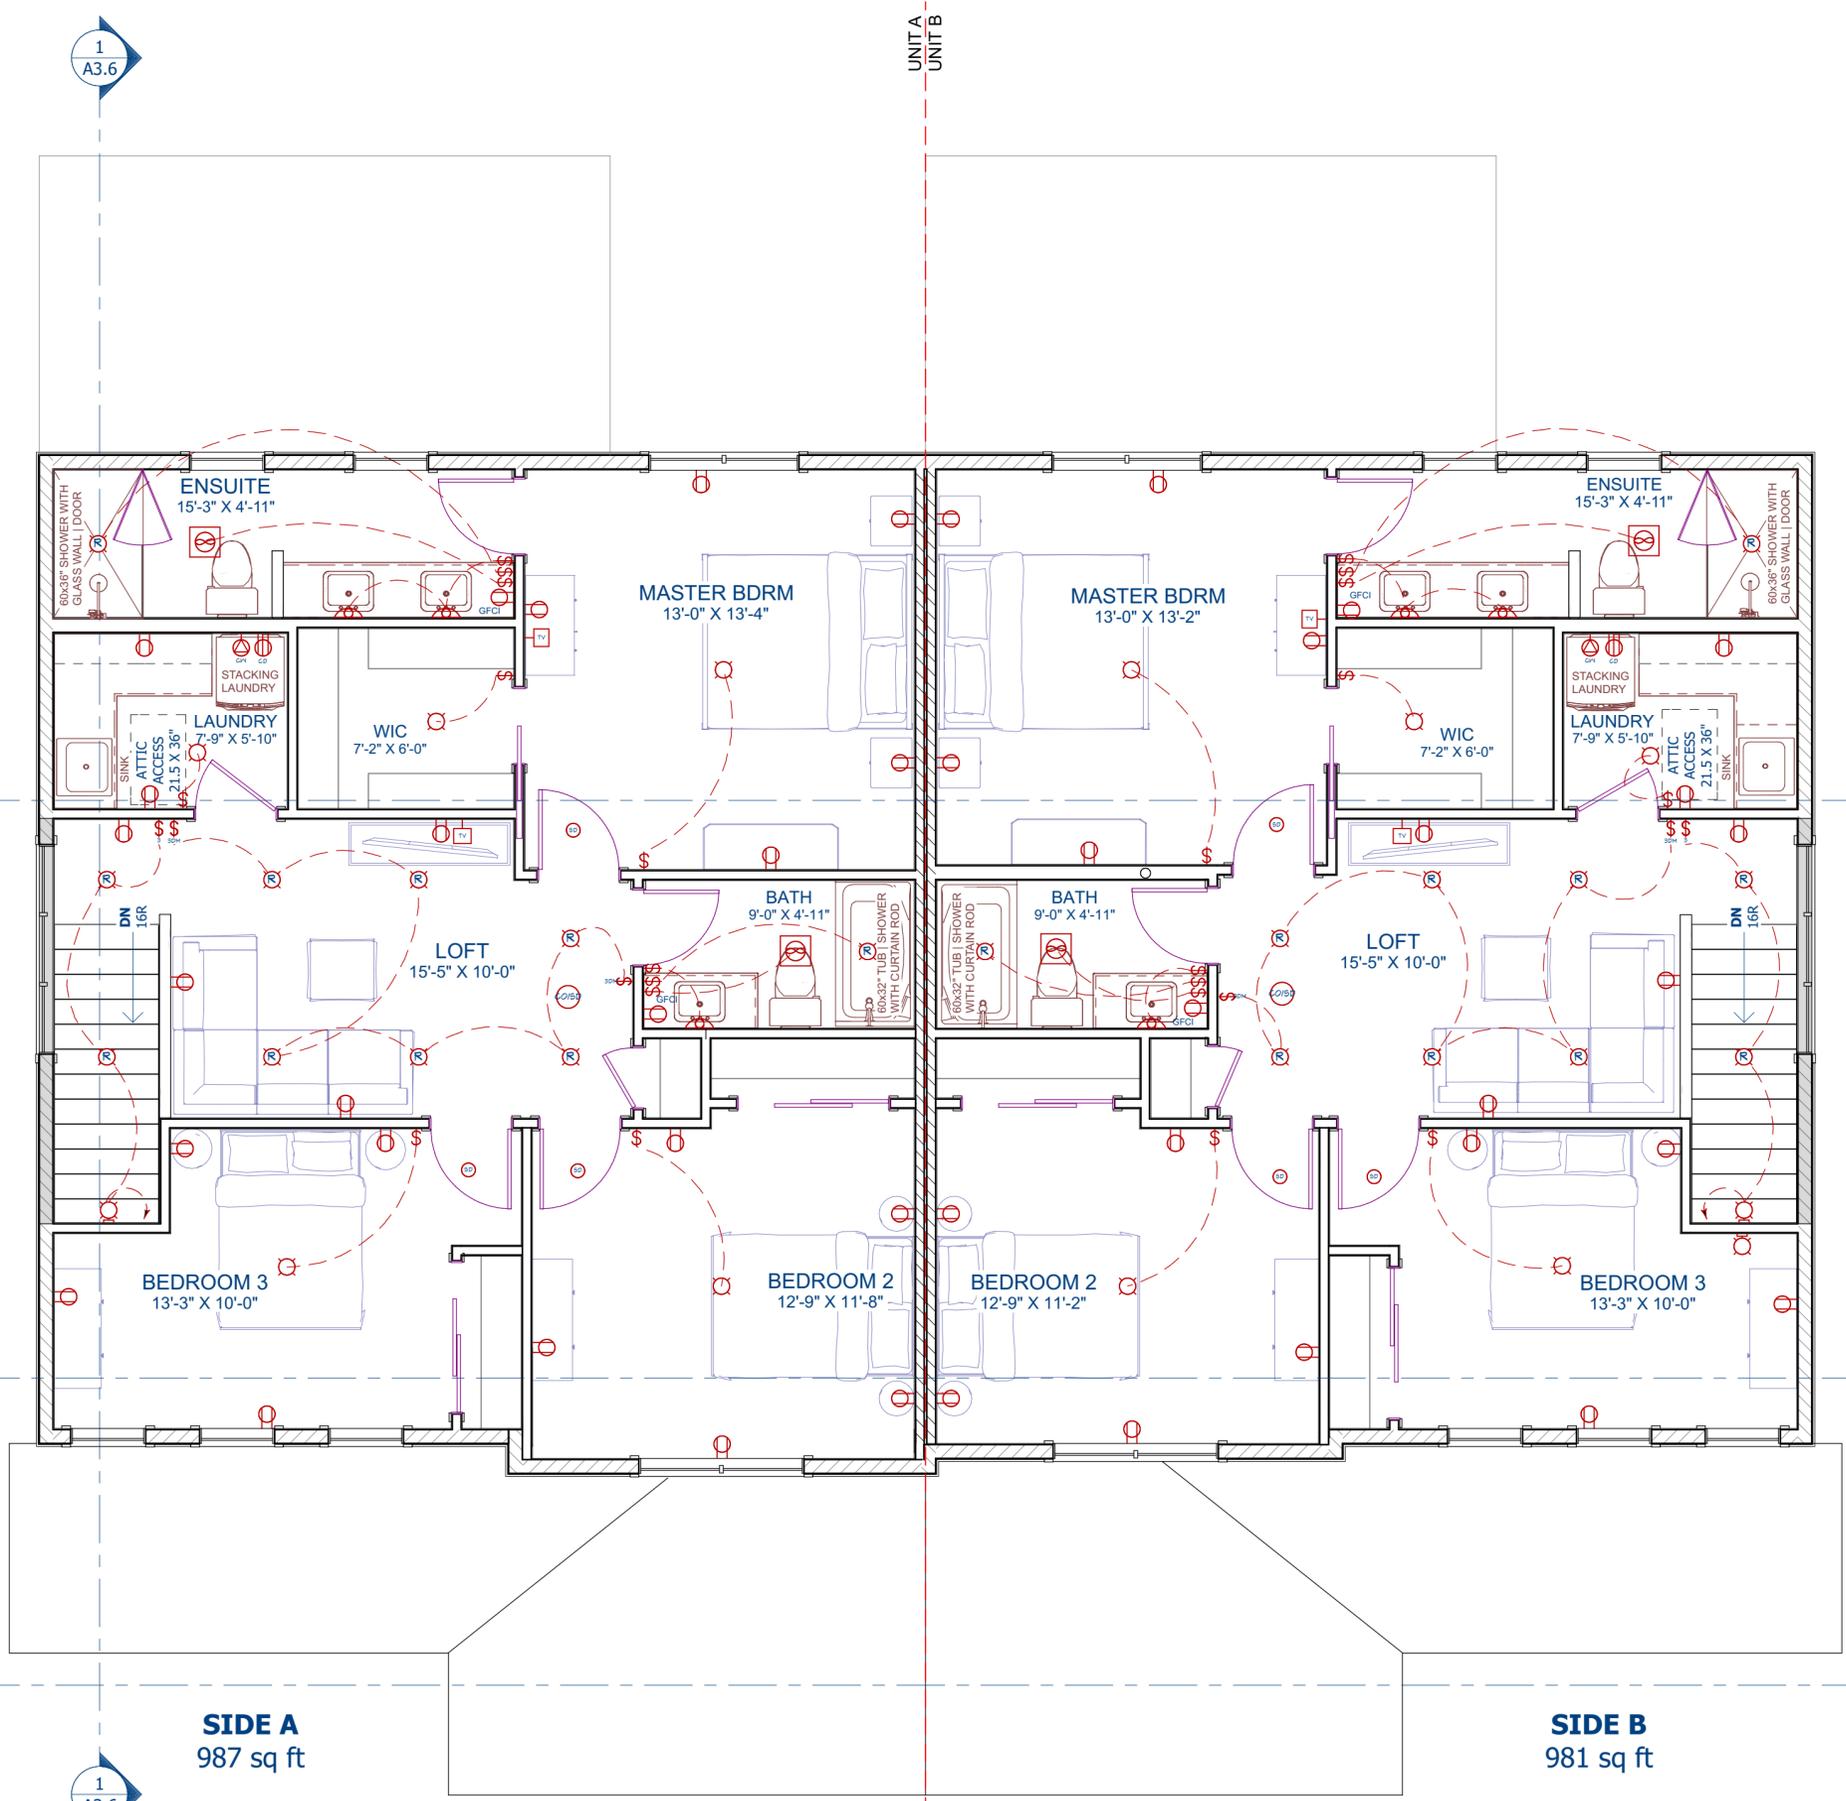

- GENERAL NOTES**
PLEASE READ CAREFULLY BEFORE BEGINNING PROJECT
- WHILE EVERY ATTEMPT HAS BEEN MADE IN THE PREPARATION OF THIS PLAN TO AVOID MISTAKES, THE DESIGNER CANNOT GUARANTEE AGAINST HUMAN ERROR.
 - THE DESIGNER IS UNABLE TO ACCEPT ANY LIABILITY FOR THE ACCURACY OR OVERALL INTEGRITY OF THESE DRAWINGS.
 - DRAWINGS ARE NOT TO BE SCALED.
 - ALL DRAWINGS, DIMENSIONS, DETAILS, AND NOTES TO BE REVIEWED AND CONFIRMED BY THE GENERAL CONTRACTOR BEFORE UNDERTAKING ANY WORK ON THE PROJECT. ANY DISCREPANCIES, ERRORS OR OMISSIONS TO BE REPORTED TO THE DESIGNER IMMEDIATELY BEFORE ORDERING MATERIALS OR COMMENCING CONSTRUCTION.
 - DESIGNER IS NOT RESPONSIBLE FOR ERRORS AND OMISSIONS IN STRUCTURAL DESIGN. ALL STRUCTURAL SYSTEMS TO BE ENGINEERED BY OTHERS. STRUCTURAL LOCATIONS AND SIZES OF SONOTUBES, COLUMNS, FOOTINGS, AND BEAMS ARE A GUIDE ONLY; THEY MUST BE VERIFIED BY TRUSS / FLOOR MANUFACTURER BEFORE CONSTRUCTION BEGINS.
 - ALL SITE DIMENSIONS AND MEASUREMENTS ARE TO BE GOVERNED AND APPROVED BY MUNICIPAL AUTHORITIES BEFORE STARTING CONSTRUCTION.
 - ALL CONSTRUCTION TO COMPLY WITH CURRENT BUILDING CODE, REGULATIONS, RULES AND BYLAWS SET BY THE AUTHORITY HAVING JURISDICTION.
 - ALL CONSTRUCTION TO COMPLY WITH INDUSTRY TRADE STANDARDS AND MANUFACTURER'S RECOMMENDATIONS WHERE THESE INSTRUCTIONS AND RECOMMENDATIONS ARE MORE STRINGENT THAN THAT CONTAINED ON THE DRAWING. ALL MATERIALS AND ENGINEERED COMPONENTS TO BE INSTALLED TO MANUFACTURER'S SPECIFICATIONS AND AS PER ENGINEERED DRAWINGS.
 - FOUNDATION AND FOOTING DESIGN ARE TYPICAL ONLY AND ASSUME STANDARD SOIL CONDITIONS AS OUTLINED IN THE BC BUILDING CODE, LATEST EDITION. IT IS THE RESPONSIBILITY OF THE OWNER / GENERAL CONTRACTOR TO CONFIRM SITE CONDITIONS AND PROVIDE ENGINEERING IF REQUIRED.
 - GENERAL CONTRACTOR TO CONFIRM FOUNDATION WALLS MEET REQUIRED BACKFILL HEIGHTS, SPECIFIED WALLS AND GRADES TO BE ADJUSTED TO SUIT SITE CONDITIONS. EXTERIOR GRADE & ALL ELEMENTS AFFECTED BY FINAL GRADE ARE TO BE CONFIRMED PRIOR TO CONSTRUCTION (BY OTHER).
 - ALL WOOD FRAMING TO BE SPF #2 OR BETTER. ANY LUMBER IN CONTACT WITH CONCRETE MUST BE "PRESERVED WOOD FOUNDATION" (PW) MATERIAL.
 - ALL LOADING & DRIFTING ARE TO BE DESIGNED BY OTHERS.
 - PLUMBING, ELECTRICAL & HEATING BY CONTRACTOR TO CODE, LATEST EDITION.
 - ROOF VENTS INSTALLED IN ACCORDANCE WITH THE BC BUILDING CODE 9.19.1.
 - IN-FLOOR HEATED CONCRETE SYSTEM BY OTHERS. PROVISIONS TO BE MADE FOR SOIL GAS CONTROL AS PER BC BUILDING CODE 9.13.4.
 - STAIRS AND HANDRAILS INSTALLED IN ACCORDANCE WITH THE BC BUILDING CODE 9.8.
 - DOOR AND WINDOW SIZES ARE APPROXIMATE AND MAY VARY BETWEEN MANUFACTURERS. ACTUAL SIZES AND ROUGH OPENINGS TO BE OBTAINED FROM SUPPLIER. ALL DOORS & WINDOWS MUST BE MARK COMPLIANT WHERE APPLICABLE AND IN ACCORDANCE WITH BC BUILDING CODE. DOORS BETWEEN HOUSE AND GARAGE TO HAVE SELF-CLOSING MECHANISM AND WEATHER STRIPPING. FIRE RATED DOORS / W SELF CLOSURES TO BE INSTALLED IN ALL FIRE RATED WALLS.
 - INFORMATION ON THESE DRAWINGS ASSUME THE AREA OF DOORS AND WINDOWS DO NOT EXCEED THE MAXIMUM TO WALL AREA OF 25% UNLESS NOTED OTHERWISE.
 - WALLS GREATER THAN 12'-0" IN HEIGHT TO COMPLY WITH THE LOCAL JURISDICTION'S GLUE FOR TALL WALLS (WHERE APPLICABLE) OR BE ENGINEERED.
 - WORKING DRAWINGS ARE A GRAPHIC REPRESENTATION ONLY - ACTUAL PRODUCTS AND MATERIALS USED MAY VARY FROM THE DIRECTION ON DRAWING.
 - ENGINEERS DRAWINGS AND/OR STAMP AS REQUIRED SHALL BE THE RESPONSIBILITY OF THE GENERAL CONTRACTOR AND/OR THE OWNER.
 - ANYTHING NOT COVERED IN THE PLANS WILL BE OPEN FOR NEGOTIATION BETWEEN THE OWNER AND THE GENERAL CONTRACTOR.

THE INFORMATION CONTAINED ON THIS DRAWING HAS BEEN PREPARED FOR THE SOLE PURPOSE OF THE PROJECT DESCRIBED HEREIN AND FOR THE SOLE BENEFIT OF THE OWNER. USE OF THIS INFORMATION FOR ANY PURPOSE OTHER THAN THE PROJECT DESCRIBED HEREIN IS AT THE SOLE RISK OF THE USER. ANY UNAUTHORIZED USE OF THIS INFORMATION WILL BE CONSIDERED A BREACH OF COPYRIGHT AND MAY BE PUNISHED AS SUCH.

TIMBERS
home + building design
T 250 489 9022 | E kim@timbershbd.com

GRIFFITHS
DUPLIX

PROJECT ADDRESS
980 HAND STREET
FERNIE, BC

LEGAL ADDRESS
LOT 1/A, PLAN NEP15240,
DL 5455, KOOTENAY DISTRICT
PID: 009-503-340

ISSUE FOR REVIEW

No	REVISION	DATE	BY
1	ISSUE FOR REVIEW	11 MAR	KD

DATE: 11-MAR-24
SCALE: 1/4" = 1'-0"

E1.3